

EXISTING PLAN LAYOUT

THIS DRAWING IS THE PROPERTY OF SHALEEN CONSULTANTS AND IS NOT TO BE COPIED OR USED WITHOUT THEIR PRIOR PERMISSION.

NOTES:

*ALL DIMENSIONS SHALL BE CHECKED AND
CO-RELATED WITH THE ARCHITECTURAL DRAWING
AND ANY AMBIGUITY SHALL BE IMMEDIATELY
BOUGHT TO THE NOTICE OF THE ARCHITECT /
CONSULTANT BEFORE COMMENCEMENT OF THE
WORK.

ALL DIMENSIONS ARE IN M. UNLESS OTHERWISE SPECIFIED

PROJECT:

IIM LUCKNOW_BG2_FIRST FLOOR_ TOILETBLOCK-2nd

DRAWING TITLE:


EXISTING PLAN LAYOUT

			DRAWN BY	AYUSH
			DATE	28-10-24
			SCALE	1: 100
			DRG. NO.	ARCH.001
	REV.	DATE	PEMAI	oks.

NO.	DATE	REMARKS	

CONSULTANTS

SHALEEN CONSULTANTS AR, PAWAN MISHRA
AR, YATI KUMAR MISHRA
2nd floor, Aishwaya Plaza-1, Sector-H, Aliganj, Lucknow
312, Skyline Plaza-1, Shushant Golf City, Lucknow
E-Mall: infoxAbleenconsultants@gmail.com
Contact No.: +91 9335920481 | +91 8896832308

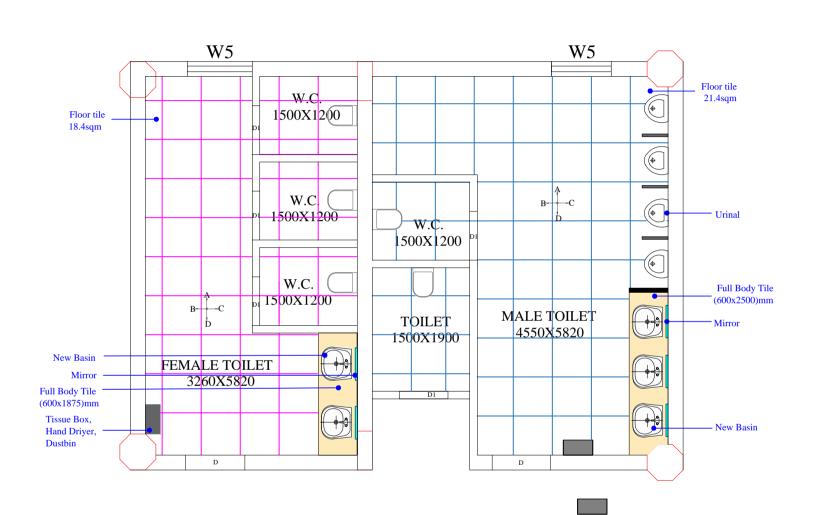

PROPOSED PLAN LAYOUT

THIS DRAWING IS THE PROPERTY OF SHALEEN CONSULTANTS AND IS NOT TO BE COPIED OR USED WITHOUT THEIR PRIOR PERMISSION.

NOTES:

*ALL DIMENSIONS SHALL BE CHECKED AND
CO-RELATED WITH THE ARCHITECTURAL DRAWING
AND ANY AMBIGUITY SHALL BE IMMEDIATELY
BOUGHT TO THE NOTICE OF THE ARCHITECT /
CONSULTANT BEFORE COMMENCEMENT OF THE
WORK.

ALL DIMENSIONS ARE IN M. UNLESS OTHERWISE SPECIFIED

PROJECT:

IIM LUCKNOW_BG2_FIRST FLOOR_ TOILETBLOCK-2nd

DRAWING TITLE:


PROPOSED PLAN LAYOUT

			DRAWN BY	AYUSH
			DATE	28-10-24
			SCALE	1: 100
			DRG. NO.	ARCH.001
	REV.	DATE	REMAR	 RKS

NO.	DATE	REMARKS

CONSULTANTS

SHALEEN CONSULTANTS
AR PAWAN MISHRA
AR YATI KUMAR MISHRA
2nd floor, Jaishways Pitzz-1, Secoreth, Aligani, Lucknow
312, Styline Plaza-1, Sunsham Golf City, Lucknow
E-Mail: info.shakeencousltants@gmail.com
Contact No. : 91 9335920481 | +91 8896832308

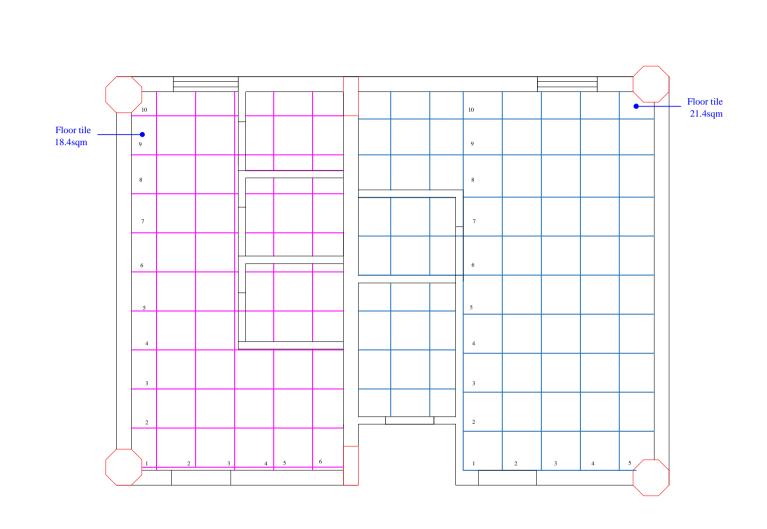

TILING LAYOUT

THIS DRAWING IS THE PROPERTY OF SHALEEN CONSULTANTS AND IS NOT TO BE COPIED OR USED WITHOUT THEIR PRIOR PERMISSION.

NOTES:

*ALL DIMENSIONS SHALL BE CHECKED AND
CO-RELATED WITH THE ARCHITECTURAL DRAWING
AND ANY AMBIGUITY SHALL BE IMMEDIATELY
BOUGHT TO THE NOTICE OF THE ARCHITECT /
COSSULTANT BEFORE COMMENCEMENT OF THE
WORK.

• ALL DIMENSIONS ARE IN M. UNLESS OTHERWISE SPECIFIED

PROJECT:

IIM LUCKNOW_BG2_FIRST FLOOR_ TOILETBLOCK-2nd

DRAWING TITLE:


TILING LAYOUT

₩÷	DRAWN BY	AYUSH	
	DATE	28-10-24	
	SCALE	1: 100	
	DRG. NO.	ARCH.001	
DEM			

REV. NO.	DATE	REMARKS

CONSULTANTS

SHALEEN
CONSULTANTS
AR, PAWAN MISHRA
AR, YATI KUMAR MISHRA
2nd floor, Aishwaye Plazarl, Scoreth-Allgain, Lucknow
312. Styline Plazar - I. Smusham Golf City, Lucknow
E-Mali; info. Shalee-consultance Wignail. com
Contact No.: +91 9335920481 | +91 8896832308

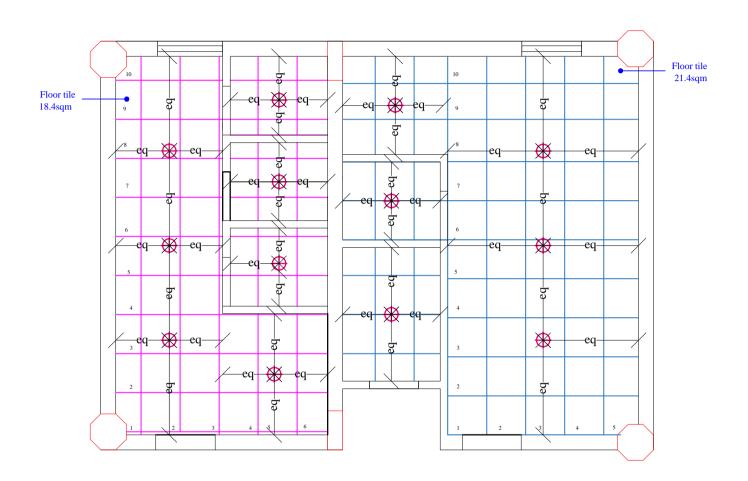

FALSE CEILING LAYOUT

THIS DRAWING IS THE PROPERTY OF SHALEEN CONSULTANTS AND IS NOT TO BE COPIED OR USED WITHOUT THEIR PRIOR PERMISSION.

NOTES:

*ALL DIMENSIONS SHALL BE CHECKED AND
CO-RELATED WITH THE ARCHITECTURAL DRAWING
AND ANY AMBIGUITY SHALL BE IMMEDIATELY
BOUGHT TO THE NOTICE OF THE ARCHITECT /
COSSULTANT BEFORE COMMENCEMENT OF THE
WORK.

• ALL DIMENSIONS ARE IN M. UNLESS OTHERWISE SPECIFIED

PROJECT:

HM LUCKNOW_BG2_FIRST FLOOR TOILETBLOCK-2nd

DRAWING TITLE:

FALSE CEILING LAYOUT


Ī	±.	DRAWN BY	AYUSH		
		N ~	DATE	26-10-24	
		SCALE	1: 100		
	7	Ŧ	DRG. NO.	ARCH.001	


REV. NO.	DATE	REMARKS

CONSULTANTS

CONSULTANTS

AR PAWAN MISHRA
AR YATI KUMAR MISHRA
2nd floor, Aishwaya Plaza-1, Sector-H. Aliganj, Lucknow
312, Skyline Plaza-1, Shusham Golf City, Lucknow
1-Mail: info.shabeneonsultanos@mail.com
Contact No.: -91 9335920481 | +91 8896832308

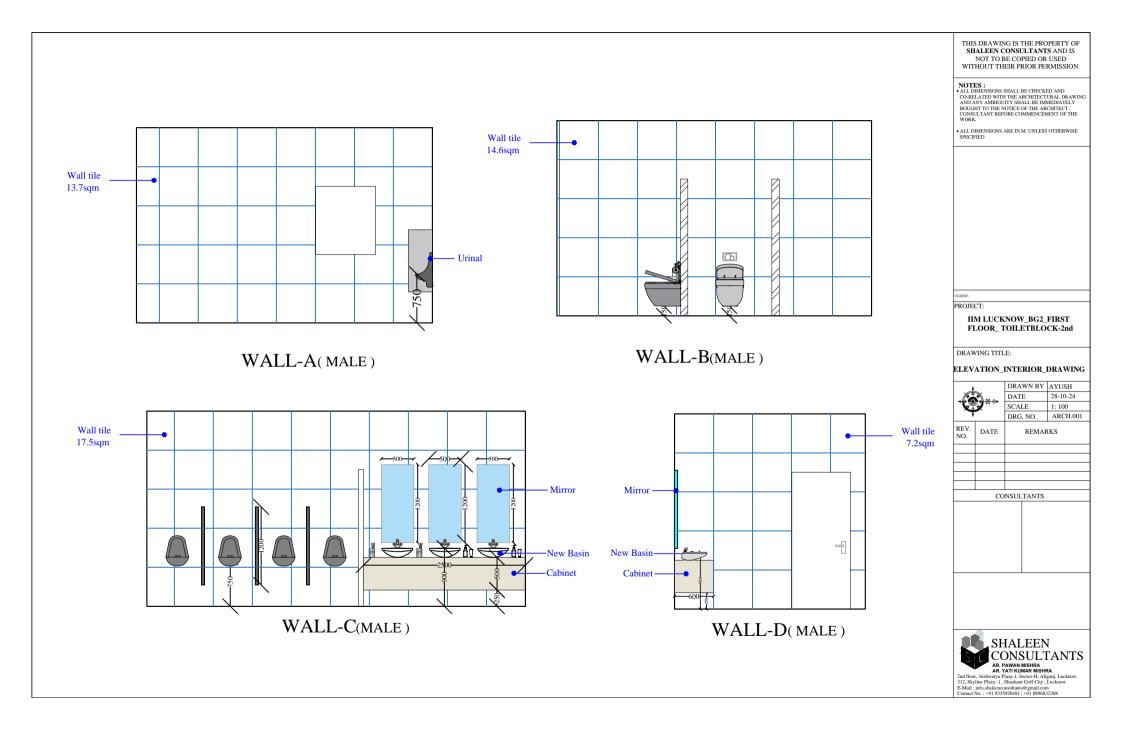

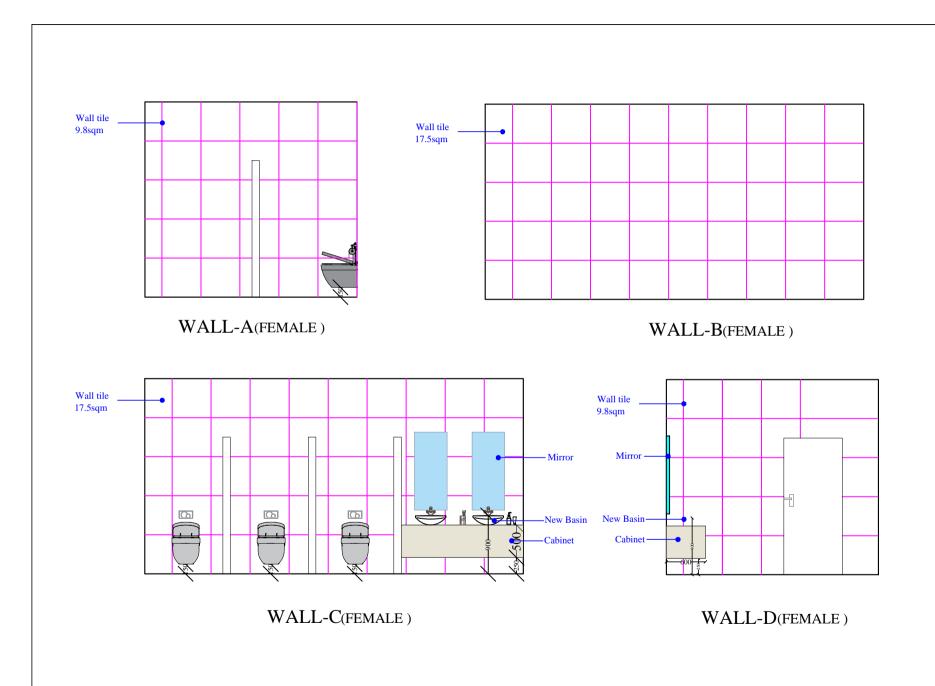

NOTES:

*ALL DIMENSIONS SHALL BE CHECKED AND
CO-RELATED WITH THE ARCHITECTURAL DRAWING
AND ANY AMBIGUITY SHALL BE IMMEDIATELY
BOUGHT TO THE NOTICE OF THE ARCHITECT /
CONSULTANT BEFORE COMMENCEMENT OF THE
WORK.


ALL DIMENSIONS ARE IN M. UNLESS OTHERWISE SPECIFIED

PROJECT:


IIM LUCKNOW_BG2_FIRST FLOOR_ TOILETBLOCK-2nd

DRAWING TITLE:


ELEVATION INTERIOR DRAWING

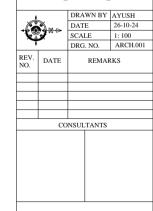



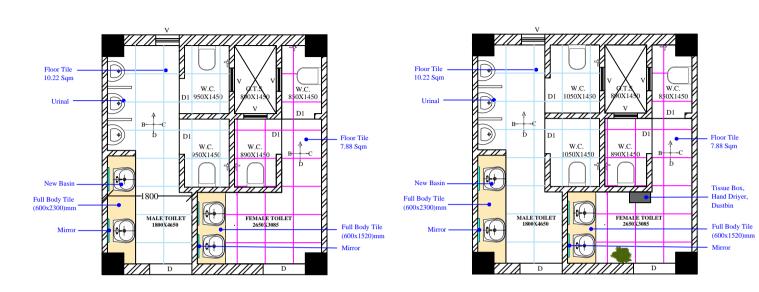


EXISTING PLAN LAYOUT

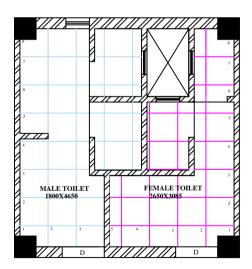

TILING LAYOUT

PROPOSED PLAN LAYOUT

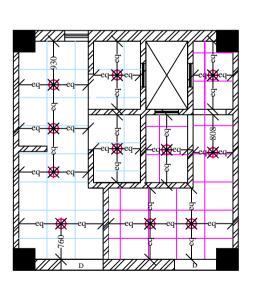

FALSE CEILING LAYOUT

THIS DRAWING IS THE PROPERTY OF SHALEEN CONSULTANTS AND IS NOT TO BE COPIED OR USED WITHOUT THEIR PRIOR PERMISSION.

NOTES:

*ALL DIMENSIONS SHALL BE CHECKED AND
CO-RELATED WITH THE ARCHITECTURAL DRAWING
AND ANY AMBIGUITY SHALL BE IMMEDIATELY
BOUGHT TO THE NOTICE OF THE ARCHITECT /
CONSULTANT BEFORE COMMENCEMENT OF THE
WORK.

•ALL DIMENSIONS ARE IN M. UNLESS OTHERWISE SPECIFIED

PROJECT:

IIM LUCKNOW COMPUTER BUILDING GROUND FLOOR_TOILET BLOCK

DRAWING TITLE:


GROUND FLOOR PLAN_TILING LAYOUT FALSE CEILING LAYOUT DRAWING


|--|--|


	DRAWN BY	AJEET
~	DATE	26-10-24
_	SCALE	1: 100
	DRG NO	ARCH 001

		Dicc		
REV. NO.	DATE		REMAR	:KS
CONSULTA			TANTS	


SHALEEN CONSULTANTS AR. PAWAN MISHRA AR. YATI KUMAR MISHRA

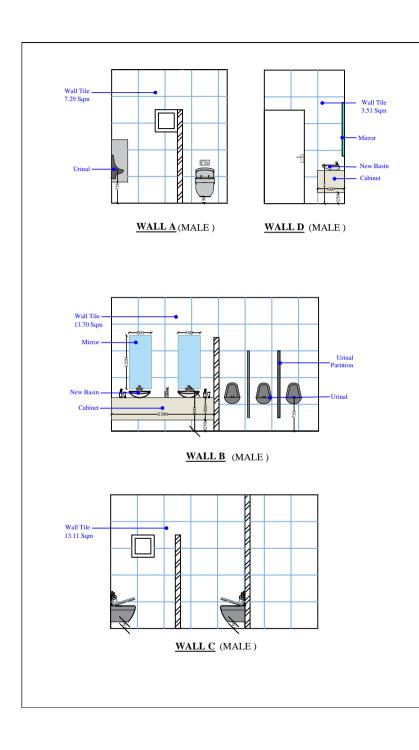

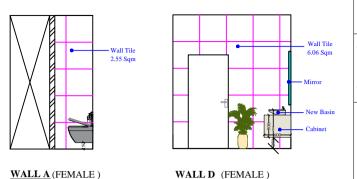

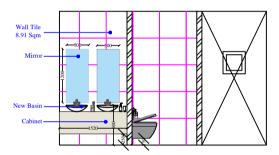

WALL B (FEMALE)

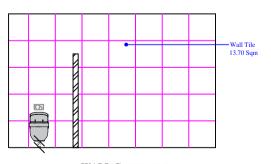

WALL C (FEMALE)

NOTES:
*ALL DIMENSIONS SHALL BE CHECKED AND
CO-RELATED WITH THE ARCHITECTURAL DRAWING
AND ANY AMBIGUITY SHALL BE IMMEDIATELY
BOUGHT TO THE NOTICE OF THE ARCHITECT /
CONSULTANT BEFORE COMMENCEMENT OF THE
WORK.

•ALL DIMENSIONS ARE IN M. UNLESS OTHERWISE SPECIFIED

PROJECT:

IIM LUCKNOW_COMPUTER BUILDING_ GROUND FLOOR TOILET BLOCK


DRAWING TITLE:

ELEVATION_INTERIOR DRAWING


₩ Þ		DRAWN BY	AJEET
		DATE	26-10-24
		SCALE	1: 100
7		DRG. NO.	ARCH.001
REV. NO. DATE		REMAR	RKS
		1	

CONSULTANTS

SHALEEN CONSULTANTS
AC. PAWADA MISHRA
AF, YATI KUMBAR MISHRA
2nd floor, Aishwaya Pitza-1, Sector-H, Aligani, Lucknow
312. Skyline Pitza-1, Shushant GOT (City, Lucknow
E-Mail: info.shabeneconsultanto@gmail.com
Connact No.: =919.355292081 | 1918.880832308

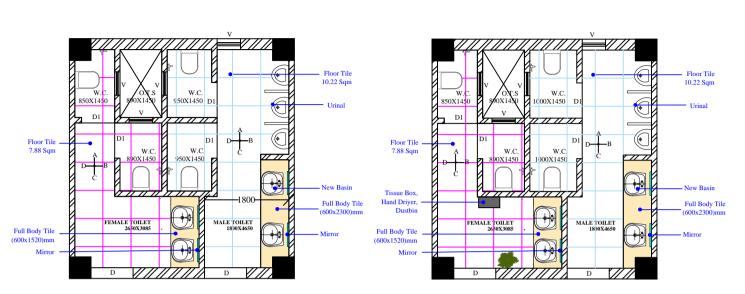


EXISTING PLAN LAYOUT

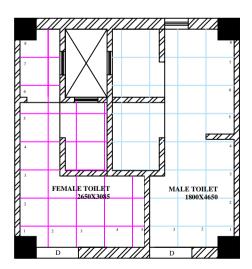

TILING LAYOUT

PROPOSED PLAN LAYOUT

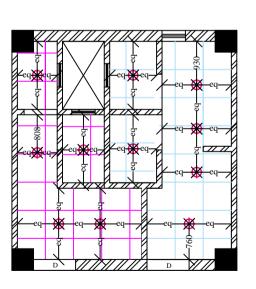

FALSE CEILING LAYOUT

THIS DRAWING IS THE PROPERTY OF SHALEEN CONSULTANTS AND IS NOT TO BE COPIED OR USED WITHOUT THEIR PRIOR PERMISSION.

NOTES:

*ALL DIMENSIONS SHALL BE CHECKED AND
CO-RELATED WITH THE ARCHITECTURAL DRAWING
AND ANY AMBIGUITY SHALL BE IMMEDIATELY
BOUGHT TO THE NOTICE OF THE ARCHITECT /
CONSULTANT BEFORE COMMENCEMENT OF THE
WORK.

•ALL DIMENSIONS ARE IN M. UNLESS OTHERWISE

PROJECT:

IIM LUCKNOW_COMPUTER BUILDING_ FIRST FLOOR TOILET BLOCK

DRAWING TITLE:

FIRST FLOOR PLAN_TILING
LAYOUT_FALSE CEILING LAYOUT
DRAWING


7


Φ.	DRAWN BY	AJEET
	DATE	26-10-24
	SCALE	1: 100
	DRG NO	ARCH 001


		SCA	LE	1: 100
		DRG	NO.	ARCH.001
REV. NO.	DATE	REMARKS		
	CO	NSUL	TANTS	




AR, PAWAN MISHRA
AR, YATI KUMAR MISHRA
2nd floor, Aishwaya Plaza-1, Sector-H, Aliganj, Lucknow
312, Skyline Plaza-1, Shushant Golf City, Lucknow
E-Mail: info.shaleenconsultanke@mail.com
Contact No.: +91 9335920481 | +91 8896832308

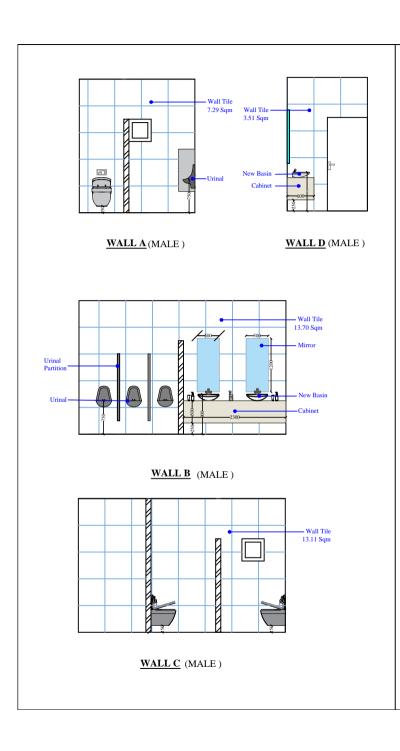

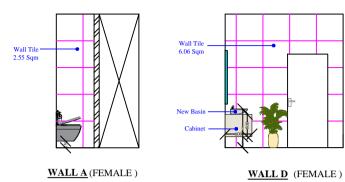

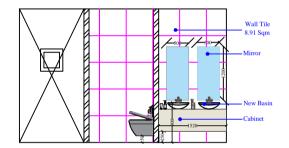

WALL B (FEMALE)

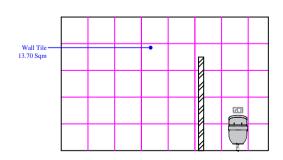

WALL C (FEMALE)

NOTES:
*ALL DIMENSIONS SHALL BE CHECKED AND
CO-RELATED WITH THE ARCHITECTURAL DRAWING
AND ANY AMBIGUITY SHALL BE IMMEDIATELY
BOUGHT TO THE NOTICE OF THE ARCHITECT /
CONSULTANT BEFORE COMMENCEMENT OF THE
WORK.


•ALL DIMENSIONS ARE IN M. UNLESS OTHERWISE SPECIFIED

PROJECT:


IIM LUCKNOW_COMPUTER BUILDING_ FIRST FLOOR_TOILET BLOCK

DRAWING TITLE:


ELEVATION INTERIOR DRAWING

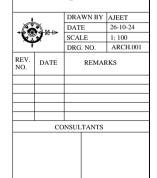




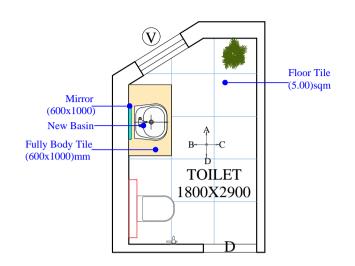

FIRST FLOOR C.A.O OFFICE TOILET

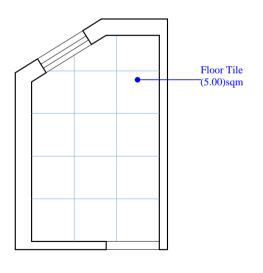



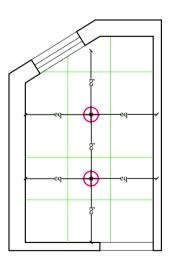

FALSE CEILING PLAN

THIS DRAWING IS THE PROPERTY OF SHALEEN CONSULTANTS AND IS NOT TO BE COPIED OR USED WITHOUT THEIR PRIOR PERMISSION.

NOTES:

• ALL DIMENSIONS SHALL BE CHECKED AND CO-RELATED WITH THE ARCHITECTURAL DRAWING AND ANY AMBIGUITY SHALL BE IMMEDIATELY BOUGHT TO THE NOTICE OF THE ARCHITECT / CONSULTANT BEFORE COMMENCEMENT OF THE WORK.

ALL DIMENSIONS ARE IN M. UNLESS OTHERWISE SPECIFIED

CLIENT:

PROJECT:

IIM _LUCKNOW_SAMADHAN BUILDING_CAO OFFICE_ TOILETBLOCK

DRAWING TITLE:

FIRSTFLOOR_PLAN,TILING, FALSE CEILING LAYOUT PLAN

29-10-2024


1: 100




		DRG	. NO.	ARCH.001
REV. NO.	DATE		REMAR	RKS
	CO	NSUL	TANTS	




E-Mail: info.shaleenconsultants@gmail.com Contact No.: +91 9335920481 | +91 8896832308

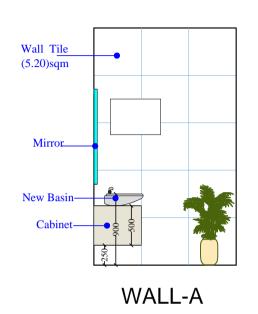

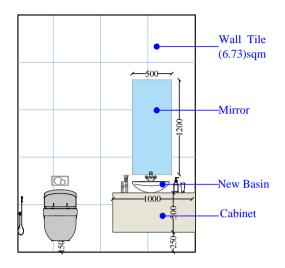

WALL-B

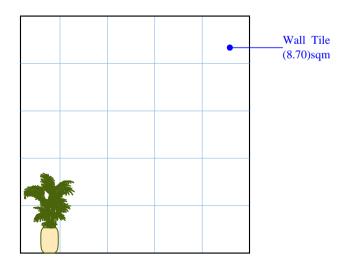



NOTES:

• ALL DIMENSIONS SHALL BE CHECKED AND CO-RELATED WITH THE ARCHITECTURAL DRAWING AND ANY AMBIGUITY SHALL BE IMMEDIATELY BOUGHT TO THE NOTICE OF THE ARCHITECT/ CONSULTANT BEFORE COMMENCEMENT OF THE WORK.

ALL DIMENSIONS ARE IN M. UNLESS OTHERWISE SPECIFIED

CLIENT:

Wall Tile

(3.77)sqm

PROJECT:

IIM _LUCKNOW_SAMADHAN BUILDING_CAO OFFICE_ TOILETBLOCK

DRAWING TITLE:

ELEVATION_INTERIOR DRAWING




↦	DRAWN BY	SUDHANSH
	DATE	29-10-2024
	SCALE	1: 100
	DDC NO	A D CIT OO I


'		DRG	. NO.	ARCH.001	
REV. NO.	DATE		REMARKS		
	CO	NSUL	TANTS		
I			1		




AR, PAWAN MISHRA
AR, YATI KUMAR MISHRA
2nd floor, Aishwaya Plaza-1, Sector-H, Aliganj, Lucknow
312, Skyline Plaza-1, Shushant Golf City, Lucknow
E-Mail: info. shaleenconsultans-8@ mail. com
Contact No.: +91 9335920481 | +91 8896832308

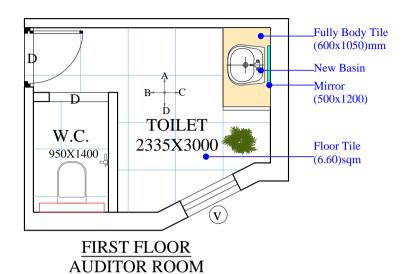

TOILET

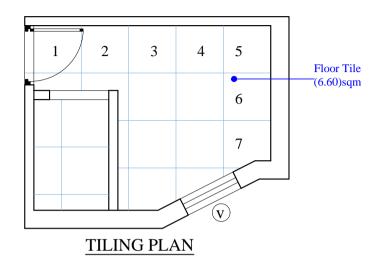

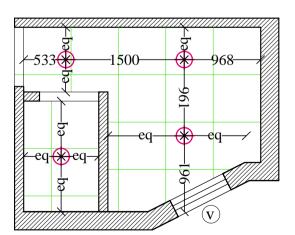

FALSE CEILING PLAN

THIS DRAWING IS THE PROPERTY OF SHALEEN CONSULTANTS AND IS NOT TO BE COPIED OR USED WITHOUT THEIR PRIOR PERMISSION.

NOTES:

• ALL DIMENSIONS SHALL BE CHECKED AND CO-RELATED WITH THE ARCHITECTURAL DRAWING AND ANY AMBIGUITY SHALL BE IMMEDIATELY BOUGHT TO THE NOTICE OF THE ARCHITECT / CONSULTANT BEFORE COMMENCEMENT OF THE WORK.

ALL DIMENSIONS ARE IN M. UNLESS OTHERWISE SPECIFIED

CLIENT:

PROJECT:

IIM LUCKNOW_SAMADHAN BUILDING AUDITOR ROOM TOILETBLOCK


DRAWING TITLE:


FIRST FLOOR TOILET BLOCK LAYOUT PLAN




₹ ±2 ₹				
7		DRG	. NO.	ARCH.001
REV. NO.	DATE	REMARKS		
	CO	NSUL	TANTS	
I			1	



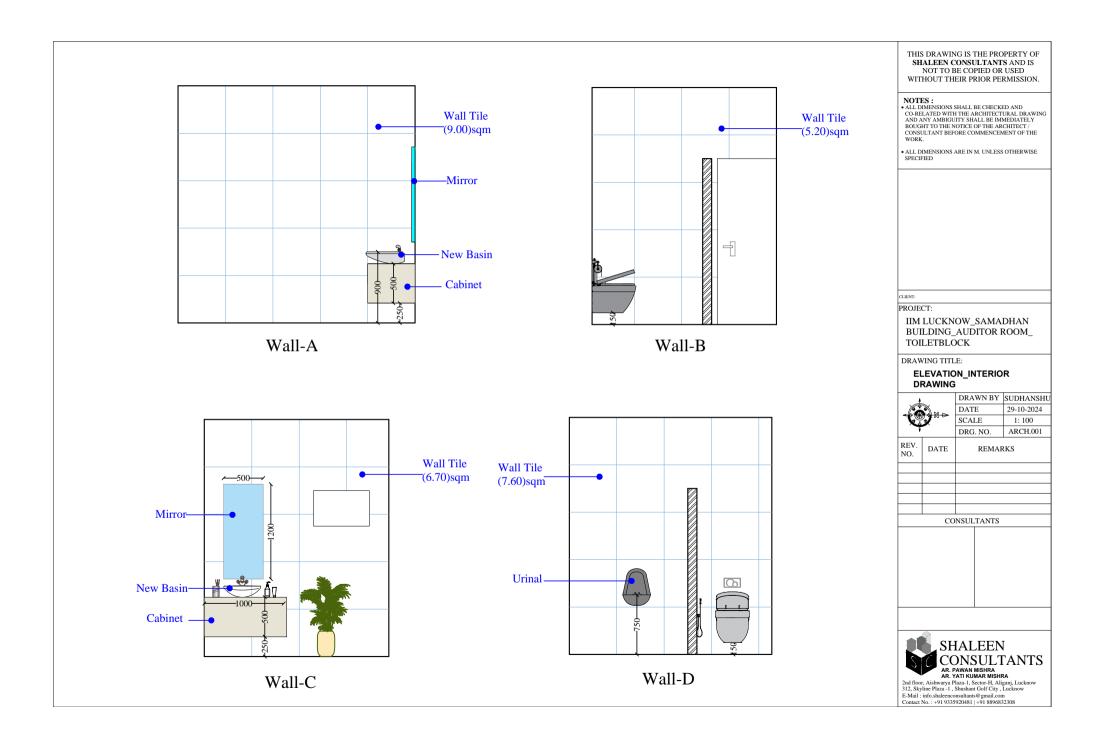


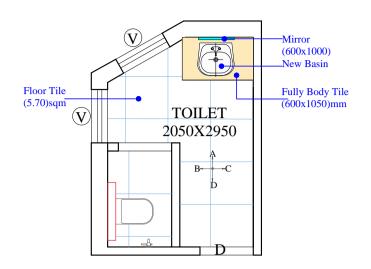

FIRST FLOOR BOARD MEETING TOILET

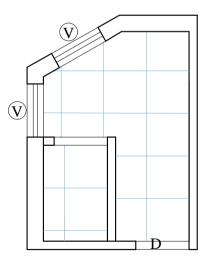

TILING PLAN

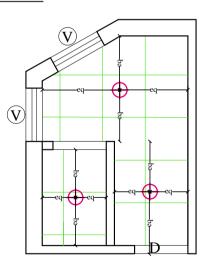

FALSE CEILING PLAN

THIS DRAWING IS THE PROPERTY OF SHALEEN CONSULTANTS AND IS NOT TO BE COPIED OR USED WITHOUT THEIR PRIOR PERMISSION.

NOTES:

• ALL DIMENSIONS SHALL BE CHECKED AND
CO-RELATED WITH THE ARCHITECTURAL DRAWING
AND ANY AMBIGUITY SHALL BE IMMEDIATELY
BOUGHT TO THE NOTICE OF THE ARCHITECT / CONSULTANT BEFORE COMMENCEMENT OF THE WORK.

ALL DIMENSIONS ARE IN M. UNLESS OTHERWISE SPECIFIED

CLIENT:

PROJECT:

IIM _LUCKNOW_SAMADHAN BUILDING_BOARD MEETING_ TOILETBLOCK

DRAWING TITLE:

FIRSTFLOOR_PLAN,TILING, FALSE CEILING LAYOUT PLAN





>	DRAWN BY	SUDHANSH
	DATE	29-10-2024
	SCALE	1: 100
	DRG. NO.	ARCH.001

DATE REMARKS NO. CONSULTANTS



E-Mail: info.shaleenconsultants@gmail.com Contact No.: +91 9335920481 | +91 8896832308

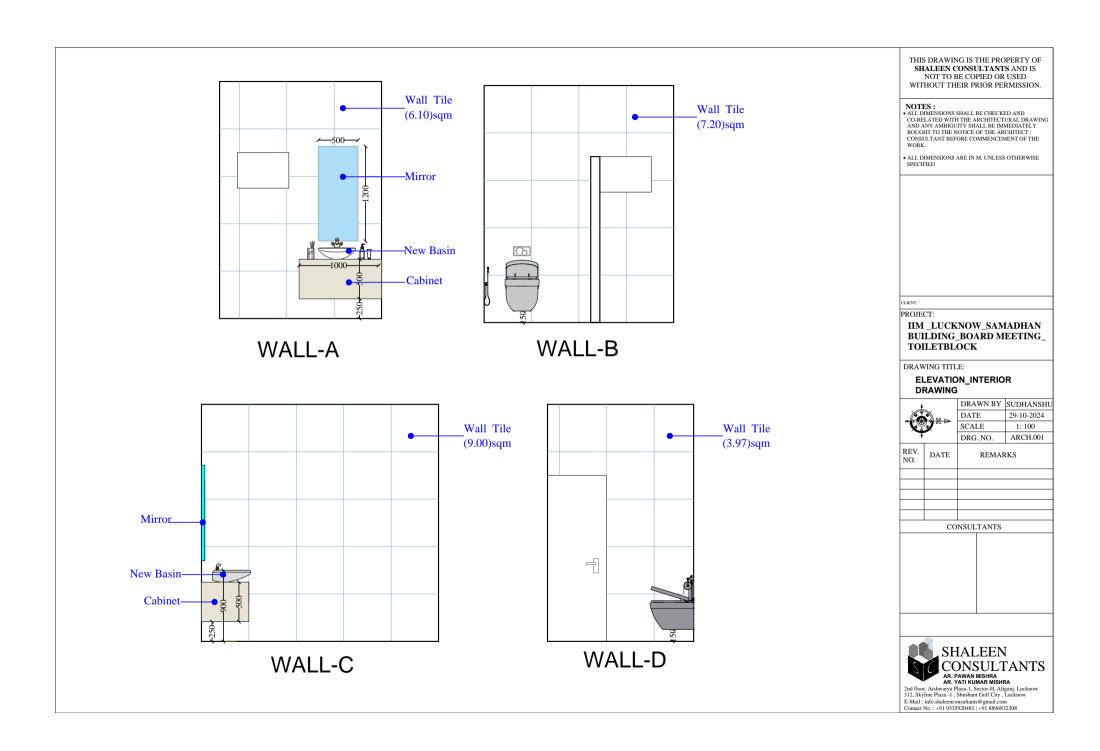

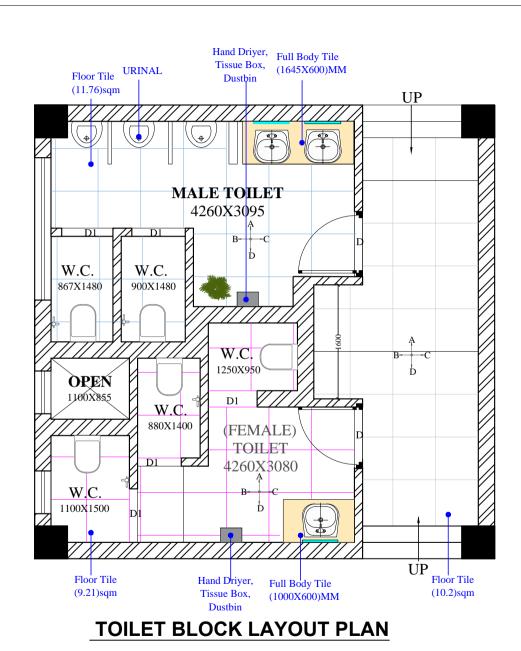

NOTES:
• ALL DIMENSIONS SHALL BE CHECKED AND CO-RELATED WITH THE ARCHITECTURAL DRAWING AND ANY AMBIGUITY SHALL BE IMMEDIATELY BOUGHT TO THE NOTICE OF THE ARCHITECT / CONSULTANT BEFORE COMMENCEMENT OF THE WORK.

ALL DIMENSIONS ARE IN M. UNLESS OTHERWISE SPECIFIED

 
CLIENT:

PROJECT:

IIM LUCKNOW_SAMADHAN BUILDING LOWER GROUND FLOOR TOILETBLOCK

DRAWING TITLE:


LOWER GROUND FLOOR TOILET_BLOCK_LAYOUT_PLAN



~	DATE	28-10-2024
>	SCALE	1: 100
	DRG. NO.	ARCH.001

DATE REMARKS CONSULTANTS



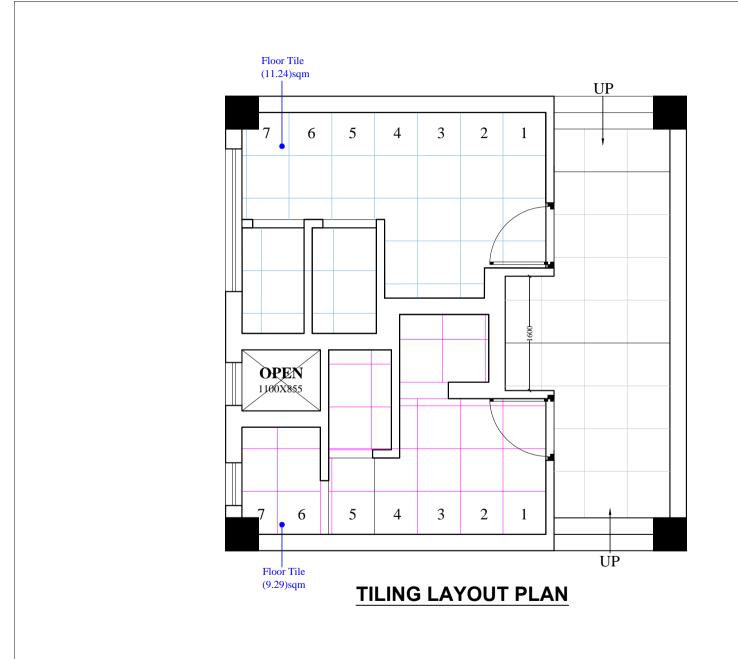

NOTES:

• ALL DIMENSIONS SHALL BE CHECKED AND CO-RELATED WITH THE ARCHITECTURAL DRAWING AND ANY AMBIGUITY SHALL BE IMMEDIATELY BOUGHT TO THE NOTICE OF THE ARCHITECT / CONSULTANT BEFORE COMMENCEMENT OF THE WORK.

ALL DIMENSIONS ARE IN M. UNLESS OTHERWISE SPECIFIED

CLIENT:

PROJECT:

IIM LUCKNOW_SAMADHAN BUILDING_LOWERGROUND FLOOR_TOILETBLOCK


DRAWING TITLE:

TILING_LAYOUT_PLAN

		DRAWN BY	SUDHANSH
		DATE	28-10-2024
		SCALE	1: 100
		DRG. NO.	ARCH.001
REV.	DATE	DEMARKS	

NO. CONSULTANTS



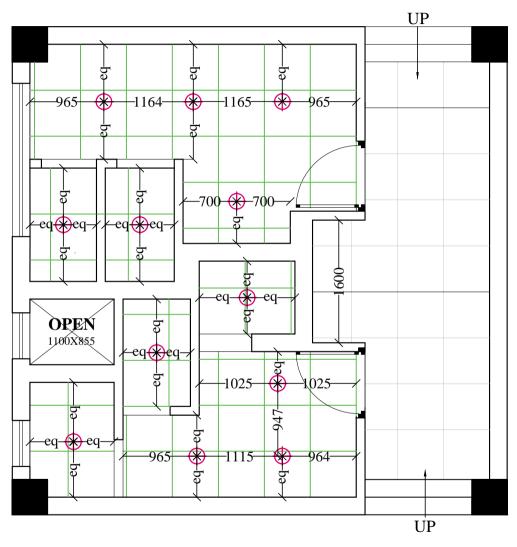

SAMADHAN TOILETBLOCK FALSE CEILING

THIS DRAWING IS THE PROPERTY OF SHALEEN CONSULTANTS AND IS NOT TO BE COPIED OR USED WITHOUT THEIR PRIOR PERMISSION.

NOTES:
• ALL DIMENSIONS SHALL BE CHECKED AND CO-RELATED WITH THE ARCHITECTURAL DRAWING AND ANY AMBIGUITY SHALL BE IMMEDIATELY BOUGHT TO THE NOTICE OF THE ARCHITECT / CONSULTANT BEFORE COMMENCEMENT OF THE WORK.

ALL DIMENSIONS ARE IN M. UNLESS OTHERWISE SPECIFIED

CLIENT:

PROJECT:


IIM LUCKNOW_SAMADHAN BUILDING_LOWER GROUND FLOOR_TOILETBLOCK


DRAWING TITLE:


FALSE_CEILING_PLAN

±		DRAWN BY	SUDHANSHU
(*) ₩→		DATE	28-10-2024
		SCALE	1: 100
7		DRG. NO.	ARCH.001
REV. NO.	DATE	REMARKS	
	CO	NSULTANTS	




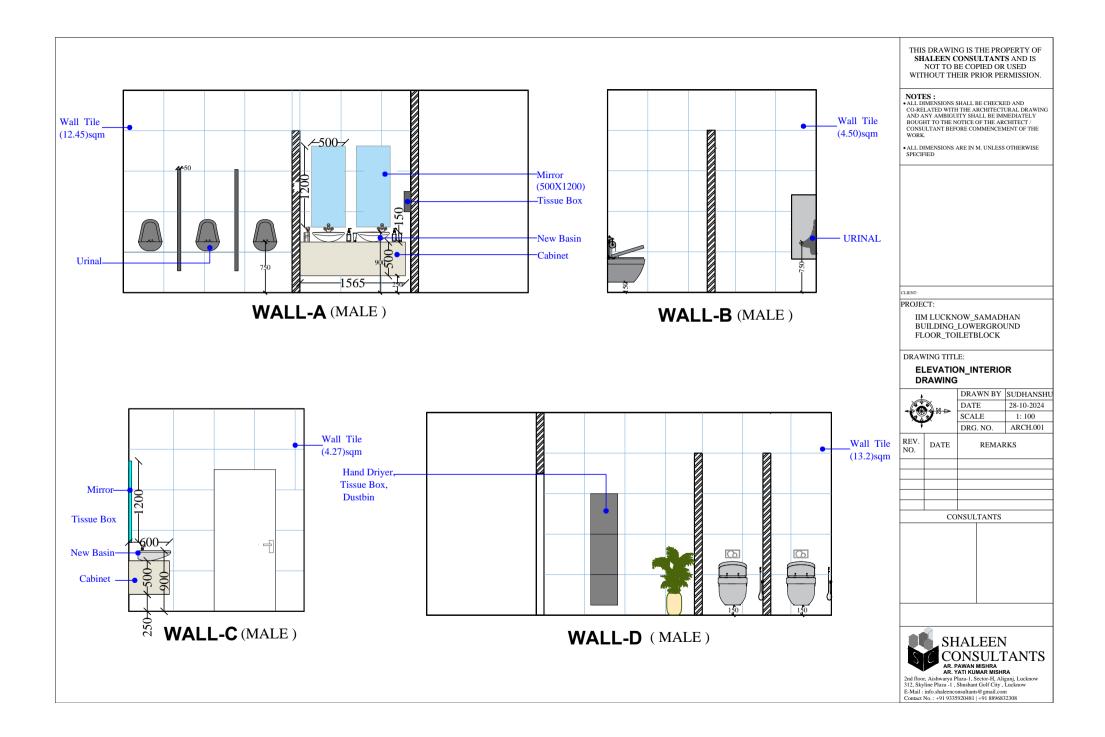

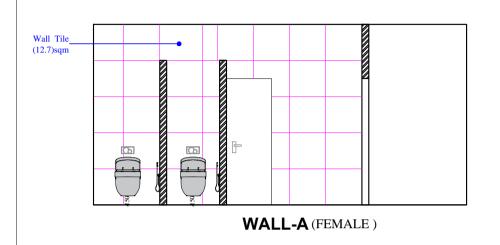

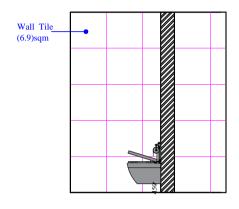

WALL-B (FEMALE)

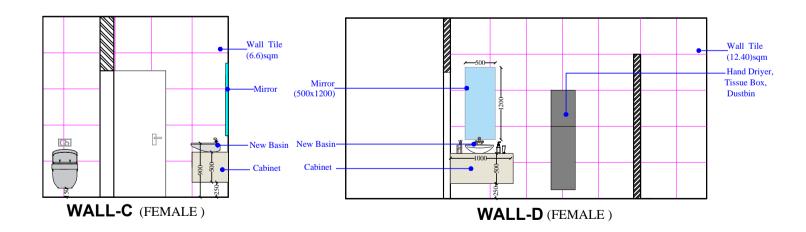

THIS DRAWING IS THE PROPERTY OF SHALEEN CONSULTANTS AND IS NOT TO BE COPIED OR USED WITHOUT THEIR PRIOR PERMISSION.

NOTES:

•ALL DIMENSIONS SHALL BE CHECKED AND
CO-RELATED WITH THE ARCHITECTURAL DRAWING
AND ANY AMBIGUITY SHALL BE IMMEDIATELY
BOUGHT TO THE NOTICE OF THE ARCHITECT / CONSULTANT BEFORE COMMENCEMENT OF THE WORK.

• ALL DIMENSIONS ARE IN M. UNLESS OTHERWISE SPECIFIED

CLIENT:

PROJECT:

IIM LUCKNOW SAMADHAN BUILDING_LOWERGROUND FLOOR_TOILETBLOCK

DRAWING TITLE:

ELEVATION_INTERIOR DRAWING


28-10-2024


1: 100





'		DRG	. NO.	ARCH.001
REV. NO.	DATE	REMARKS		
	CO	NSUL	TANTS	



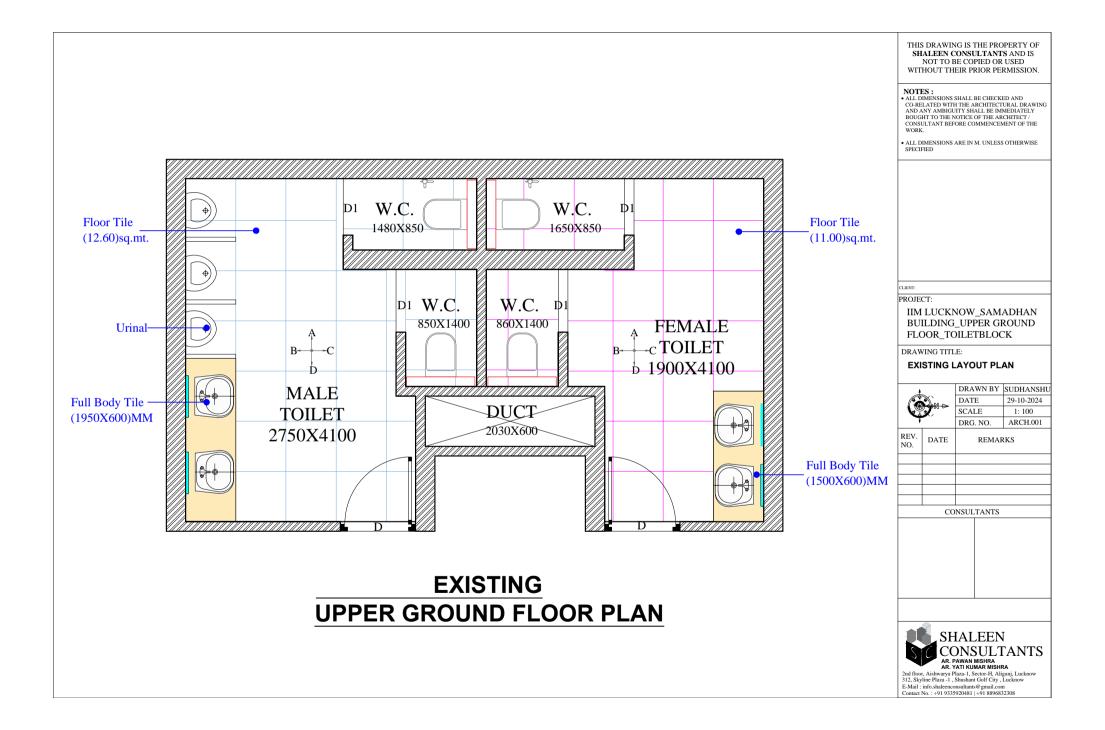

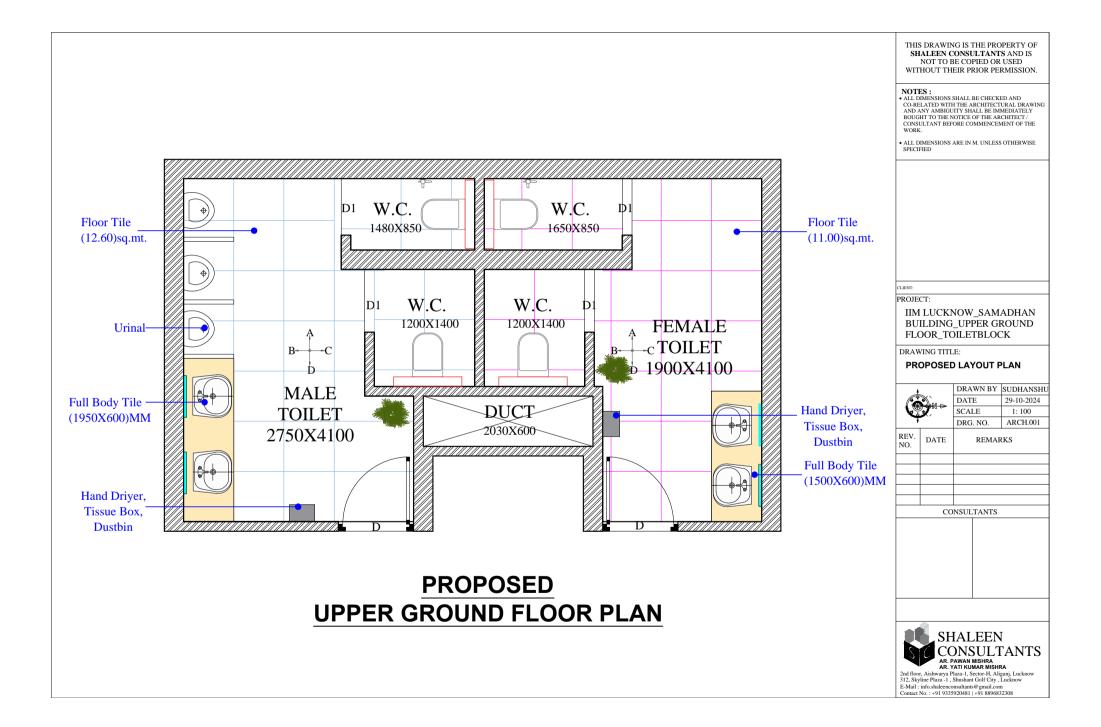

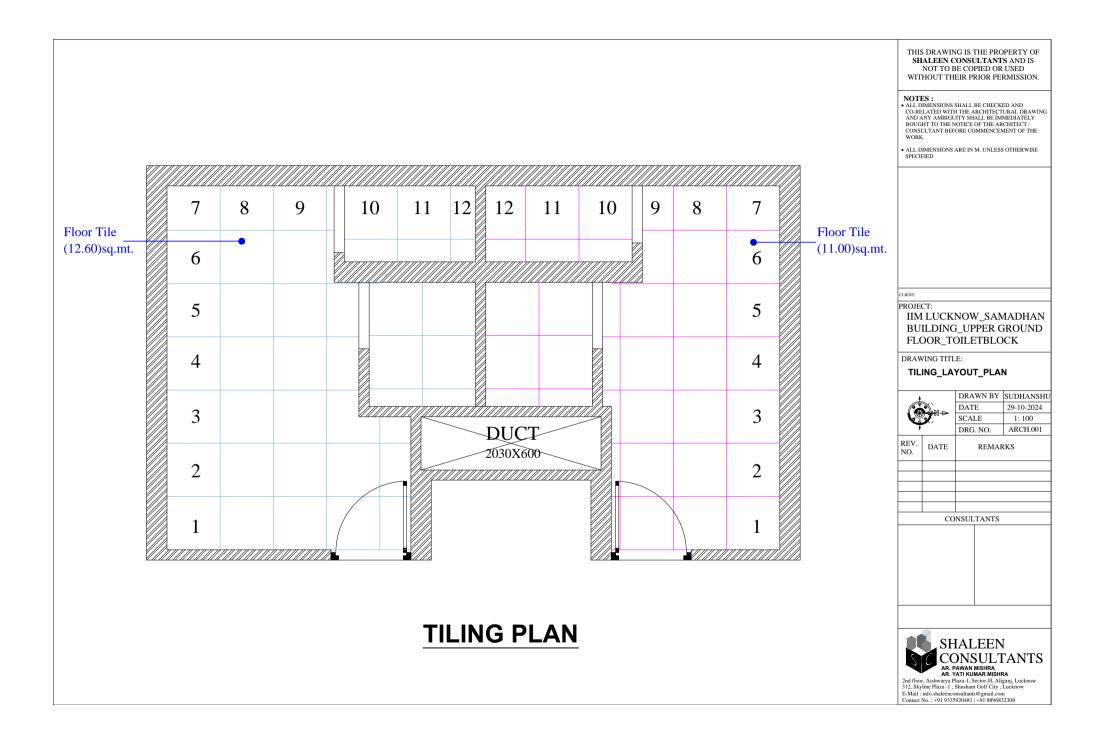

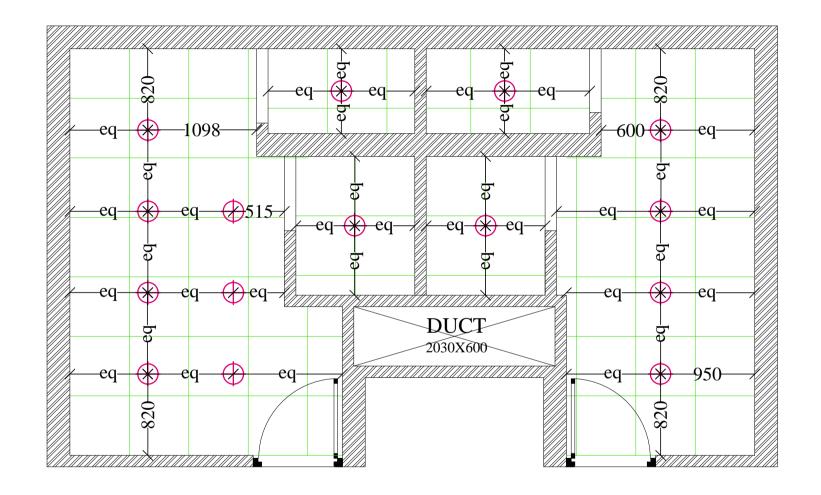

FALSE CEILING PLAN

THIS DRAWING IS THE PROPERTY OF SHALEEN CONSULTANTS AND IS NOT TO BE COPIED OR USED WITHOUT THEIR PRIOR PERMISSION.

NOTES:
• ALL DIMENSIONS SHALL BE CHECKED AND CO-RELATED WITH THE ARCHITECTURAL DRAWING AND ANY AMBIGUITY SHALL BE IMMEDIATELY BOUGHT TO THE NOTICE OF THE ARCHITECT / CONSULTANT BEFORE COMMENCEMENT OF THE WORK.

ALL DIMENSIONS ARE IN M. UNLESS OTHERWISE SPECIFIED

CLIENT:

PROJECT:


IIM LUCKNOW_SAMADHAN BUILDING_UPPER GROUND FLOOR TOILETBLOCK

DRAWING TITLE:


FALSE CEILING_LAYOUT_ PLAN






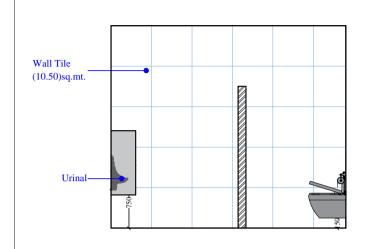


WALL-A (MALE)

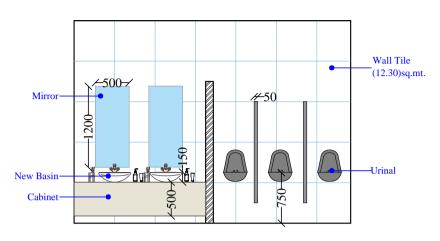

WALL-B (MALE)

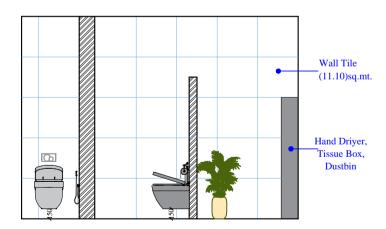

WALL-C (MALE)

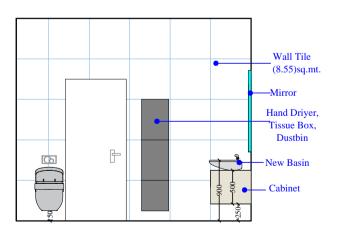

WALL-D (MALE)

NOTES:
• ALL DIMENSIONS SHALL BE CHECKED AND • ALL DIMENSIONS SHALL BE CHECKED AND CO-RELATED WITH THE ARCHITECTURAL DRAWING AND ANY AMBIGUITY SHALL BE IMMEDIATELY BOUGHT TO THE NOTICE OF THE ARCHITECT / CONSULTANT BEFORE COMMENCEMENT OF THE WORK.

ALL DIMENSIONS ARE IN M. UNLESS OTHERWISE SPECIFIED

CLIENT:

PROJECT:

IIM LUCKNOW_SAMADHAN BUILDING_UPPER GROUND FLOOR TOILETBLOCK

DRAWING TITLE:


ELEVATION_INTERIOR DRAWING




٨	DRAWN BY	SUDHANSH		
	DATE	29-10-2024		
	SCALE	1: 100		
	DRG. NO.	ARCH.001		


DATE REMARKS CONSULTANTS




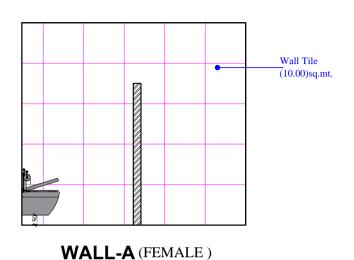

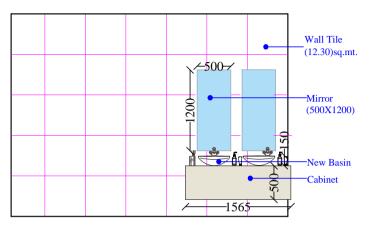

WALL-C (FEMALE)

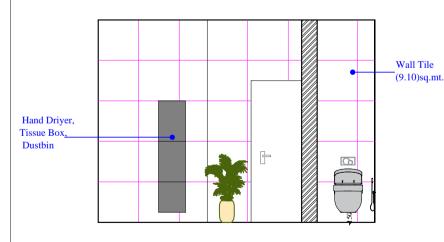

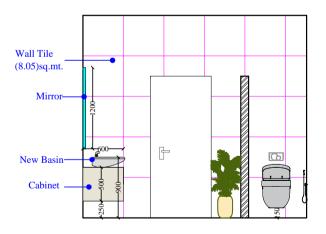

WALL-B (FEMALE)

WALL-D (FEMALE)

NOTES:
• ALL DIMENSIONS SHALL BE CHECKED AND • ALL DIMENSIONS SHALL BE CHECKED AND CO-RELATED WITH THE ARCHITECTURAL DRAWING AND ANY AMBIGUITY SHALL BE IMMEDIATELY BOUGHT TO THE NOTICE OF THE ARCHITECT / CONSULTANT BEFORE COMMENCEMENT OF THE WORK.

ALL DIMENSIONS ARE IN M. UNLESS OTHERWISE SPECIFIED

 
CLIENT:

PROJECT:

IIM LUCKNOW SAMADHAN BUILDING_UPPER GROUND FLOOR_TOILETBLOCK


DRAWING TITLE:

ELEVATION_INTERIOR DRAWING



7.0			_		
7		DRG.	NO.	ARCH.001	
REV. NO.	DATE	1	REMARKS		
	СО	NSULT	ANTS		



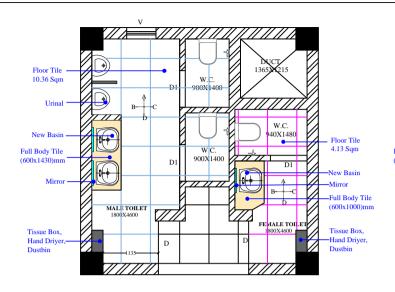


EXISTING


PLAN LAYOUT

Floor Tile W.C 10.36 Sqm 1050X1400 Urinal W.C. 940X1480 New Basin - Floor Tile 4.13 Sqm Full Body Tile 1050X1400 (600x1430)mm -Full Body Tile (600x1000)mm MALE TOILET 1800X4600 FEMALE TOILET Tissue Box, Tissue Box, -Hand Driver, Hand Driver, Dustbin Dustbin

> PROPOSED PLAN LAYOUT

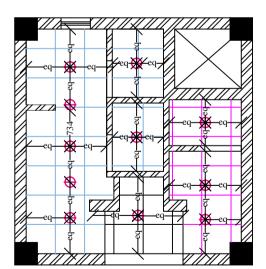

FALSE CEILING LAYOUT

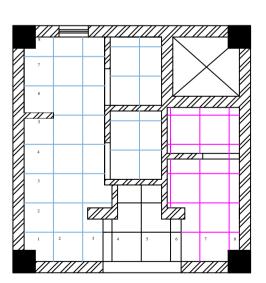

TILING LAYOUT

THIS DRAWING IS THE PROPERTY OF SHALEEN CONSULTANTS AND IS NOT TO BE COPIED OR USED WITHOUT THEIR PRIOR PERMISSION.

NOTES:

*ALL DIMENSIONS SHALL BE CHECKED AND
CO-RELATED WITH THE ARCHITECTURAL DRAWING
AND ANY AMBIGUITY SHALL BE IMMEDIATELY
BOUGHT TO THE NOTICE OF THE ARCHITECT /
CONSULTANT BEFORE COMMENCEMENT OF THE
WORK.

• ALL DIMENSIONS ARE IN M. UNLESS OTHERWISE

PROJECT:


IIM LUCKNOW_BG-1_FIRSTFLOOR_ TOILET BLOCK-1st


DRAWING TITLE: FIRST FLOOR PLAN TILING LAYOUT_FALSE CEILING LAYOUT DRAWING

DRAWN BY AJEET DATE 29-10-24 SCALE 1: 100

DRG. NO. ARCH.001 REV. DATE REMARKS NO. CONSULTANTS




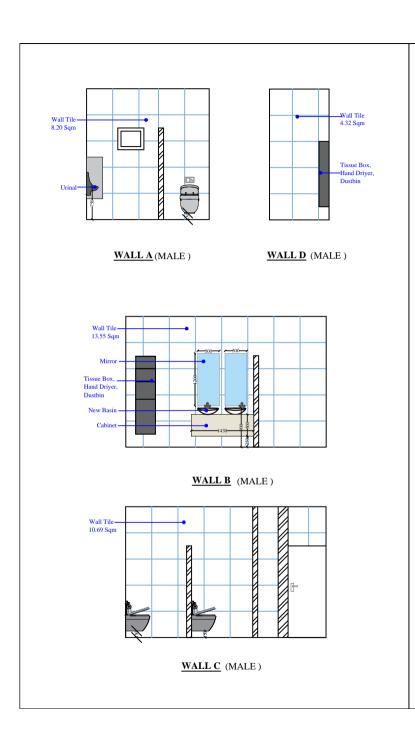

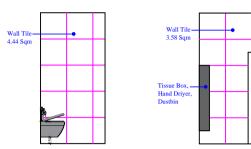


WALL A (FEMALE)

WALL D (FEMALE)

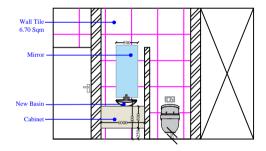

WALL B (FEMALE)

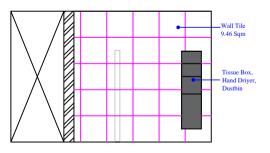

 $\underline{WALL\ C}$ (FEMALE)

THIS DRAWING IS THE PROPERTY OF SHALEEN CONSULTANTS AND IS NOT TO BE COPIED OR USED WITHOUT THEIR PRIOR PERMISSION.

NOTES:
*ALL DIMENSIONS SHALL BE CHECKED AND
CO-RELATED WITH THE ARCHITECTURAL DRAWING
AND ANY AMBIGUITY SHALL BE IMMEDIATELY
BOUGHT TO THE NOTICE OF THE ARCHITECT /
CONSULTANT BEFORE COMMENCEMENT OF THE
WORK.

•ALL DIMENSIONS ARE IN M. UNLESS OTHERWISE SPECIFIED

PROJECT:

IIM LUCKNOW_BG-1_FIRSTFLOOR_ TOILET BLOCK-1st

DRAWING TITLE:


ELEVATION_INTERIOR DRAWING





REV. NO. DATE REMARKS

CONSULTANTS

SHALEEN CONSULTANTS
AC. PAWADA MISHRA
AF, YATI KUMBAR MISHRA
2nd floor, Aishwaya Pitza-1, Sector-H, Aligani, Lucknow
312. Skyline Pitza-1, Shushant GOT (City, Lucknow
E-Mail: info.shabeneconsultanto@gmail.com
Connact No.: =919.355292081 | 1918.880832308

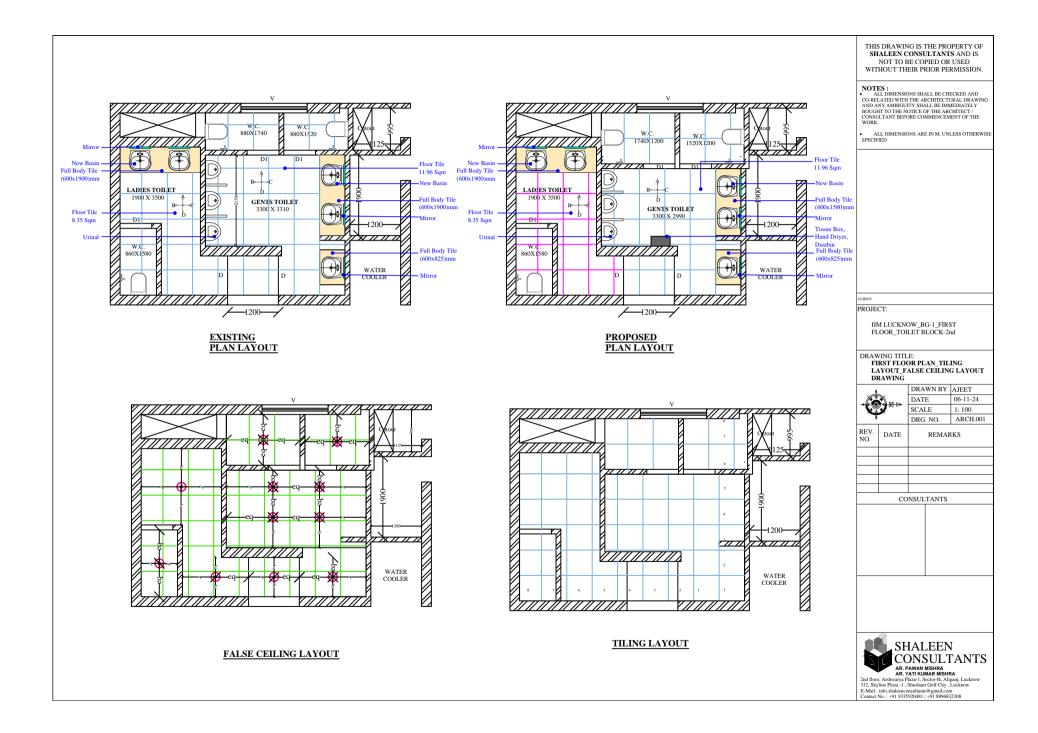


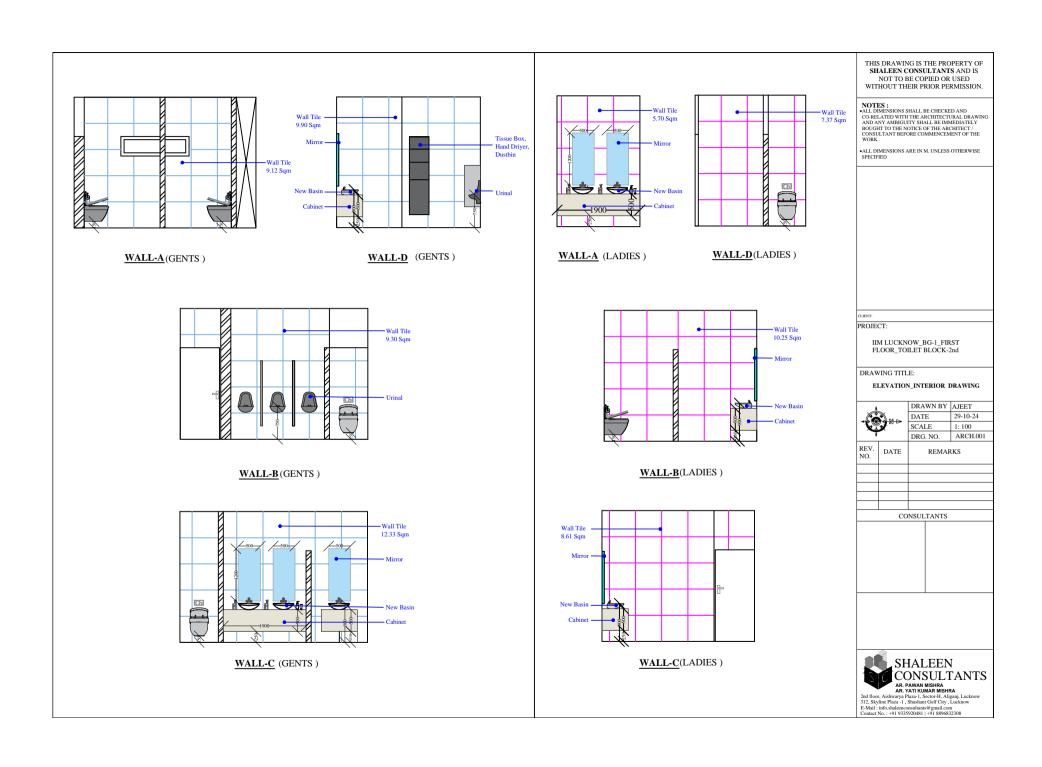

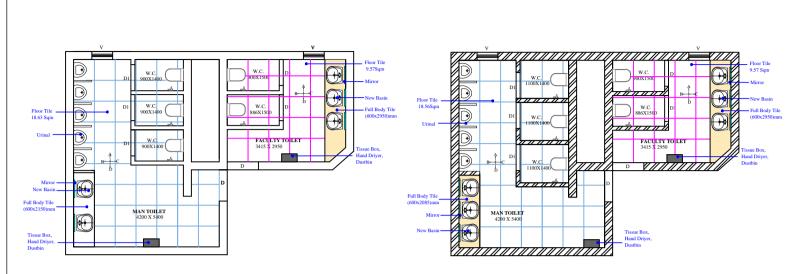


EXISTING PLAN LAYOUT



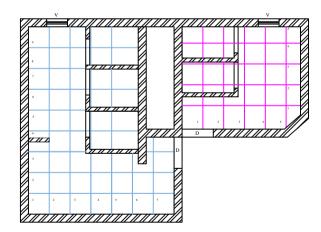

TILING LAYOUT

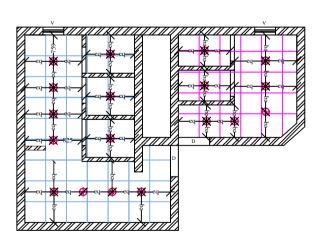

FALSE CEILING LAYOUT

THIS DRAWING IS THE PROPERTY OF SHALEEN CONSULTANTS AND IS NOT TO BE COPIED OR USED WITHOUT THEIR PRIOR PERMISSION.

NOTES:

• ALL DIMENSIONS SHALL BE CHECKED AND CO-RELATED WITH THE ARCHITECTURAL DRAWING AND ANY AMBIGUITY SHALL BE IMMEDIATELY BOUGHT TO THE NOTICE OF THE ARCHITECT / COSSULTANT BEFORE COMMENCEMENT OF THE WORK.

ALL DIMENSIONS ARE IN M. UNLESS OTHERWISE

PROJECT:

IIM LUCKNOW_BG-1_GROUNDFLOOR_ TOILET BLOCK-2nd

DRAWING TITLE: GROUND FLOOR PLAN TILING LAYOUT_FALSE CEILING LAYOUT DRAWING





⇔	DRAWN BY	AJEET
	DATE	29-10-24
	SCALE	1: 100
	DRG. NO.	ARCH.001


REV. DATE REMARKS NO. CONSULTANTS


SHALEEN CONSULTANTS

AR, PAWAN MISHRA
AR, YATI KUMAR MISHRA
2nd floor, Aishwaya Plaza-1, Sector-H, Aliganj, Lucknow
312, Skyline Plaza-1, Shushant Golf City, Lucknow
E-Mail: info sheenconsultants-6g gmail.com
Contact No.: +91 9335920481 | +91 8896832308

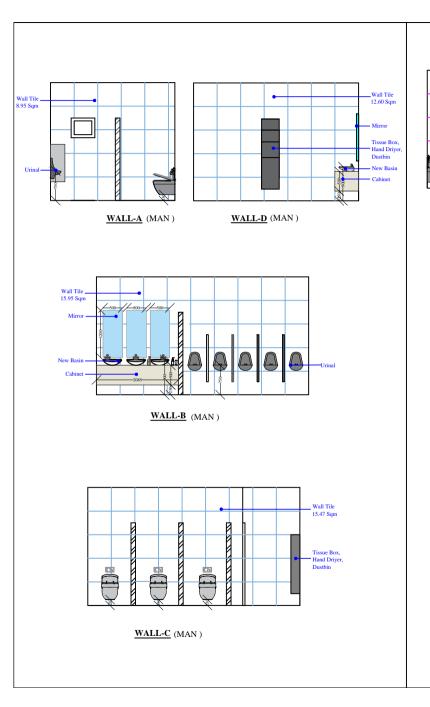

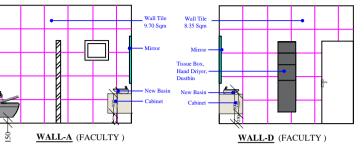

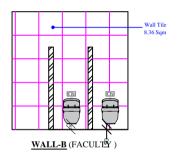

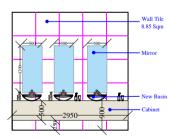

WALL-C(FACULTY)

NOTES:

• ALL DIMENSIONS SHALL BE CHECKED AND CO-RELATED WITH THE ARCHITECTURAL DRAWING AND ANY AMBIGUITY SHALL BE IMMEDIATELY BOUGHT TO THE NOTICE OF THE ARCHITECT / COSSULTANT BEFORE COMMENCEMENT OF THE WORK.

ALL DIMENSIONS ARE IN M. UNLESS OTHERWISE SPECIFIED

PROJECT:

IIM LUCKNOW_BG-1_GROUND FLOOR_TOILET BLOCK-2nd

DRAWING TITLE:

ELEVATION_INTERIOR DRAWING





	DRAWN BY	AJEET	
	DATE	29-10-24	
	SCALE	1: 100	
	DRG NO	ARCH 001	


		DKG	. NO.	ARCH.001
REV. NO.	DATE	REMARKS		
	CO	NSUL	TANTS	


SHALEEN CONSULTANTS

AR, PAWAN MISHRA
AR, YATI KUMAR MISHRA
2nd floor, Aishwaya Plaza-1, Sector-H, Aliganj, Lucknow
312, Skyline Plaza-1, Shushan Golf City, Lucknow
E-Mail: info.shaleenconsulantes @gmail.com
Comact No.: -91 9335920481 | +91 8896832308

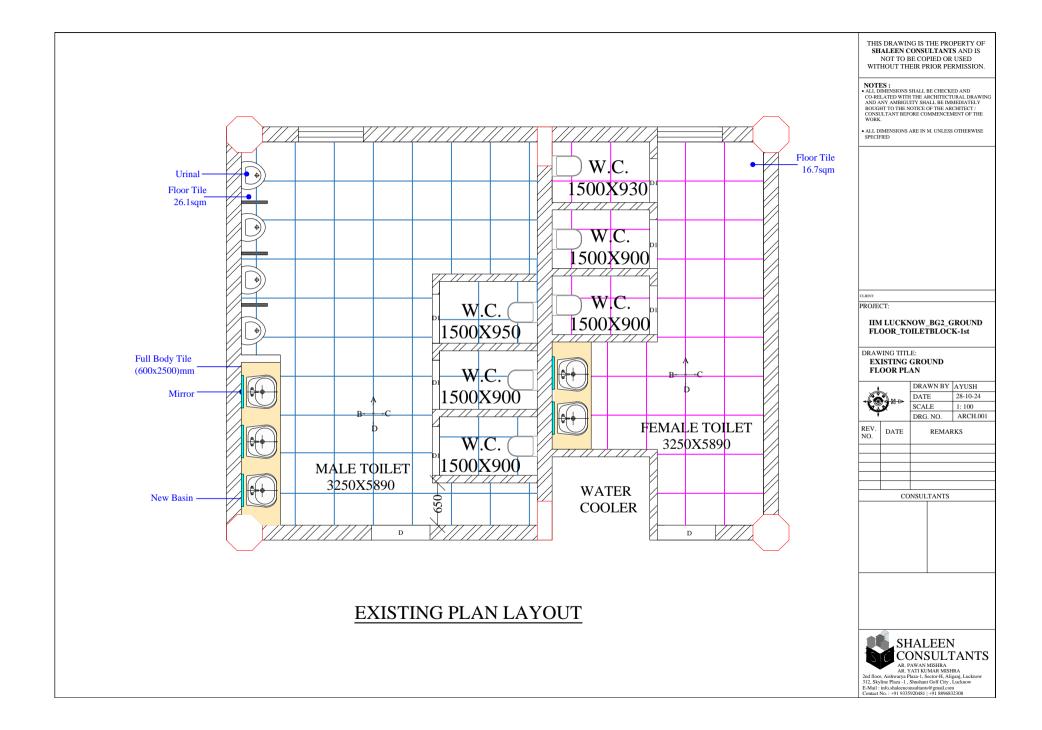

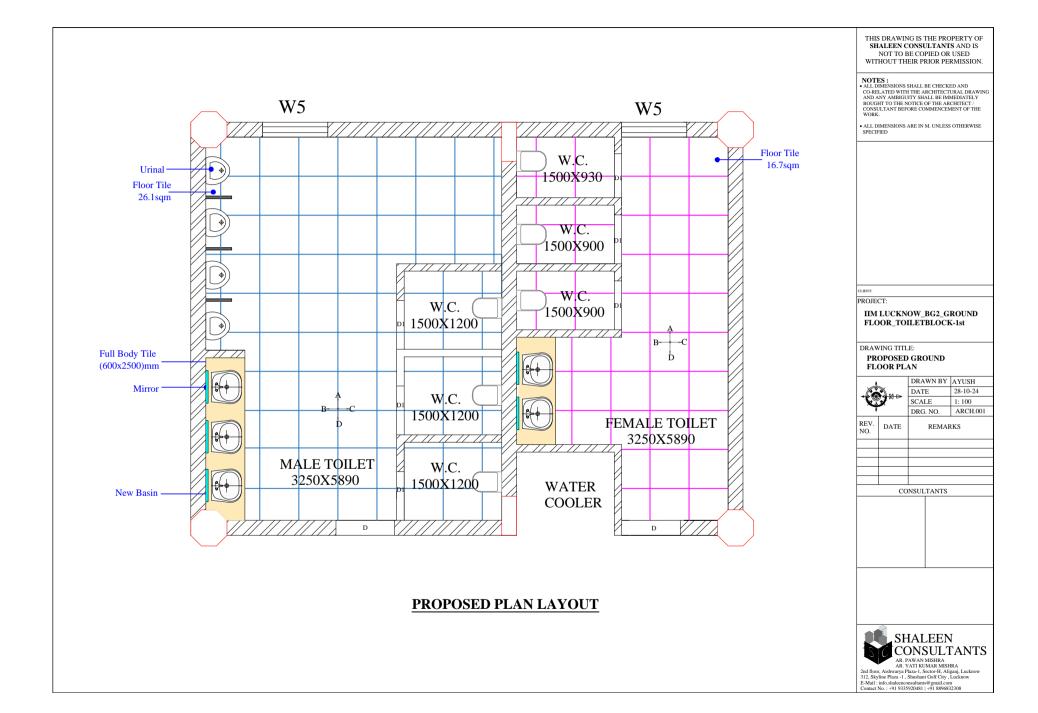

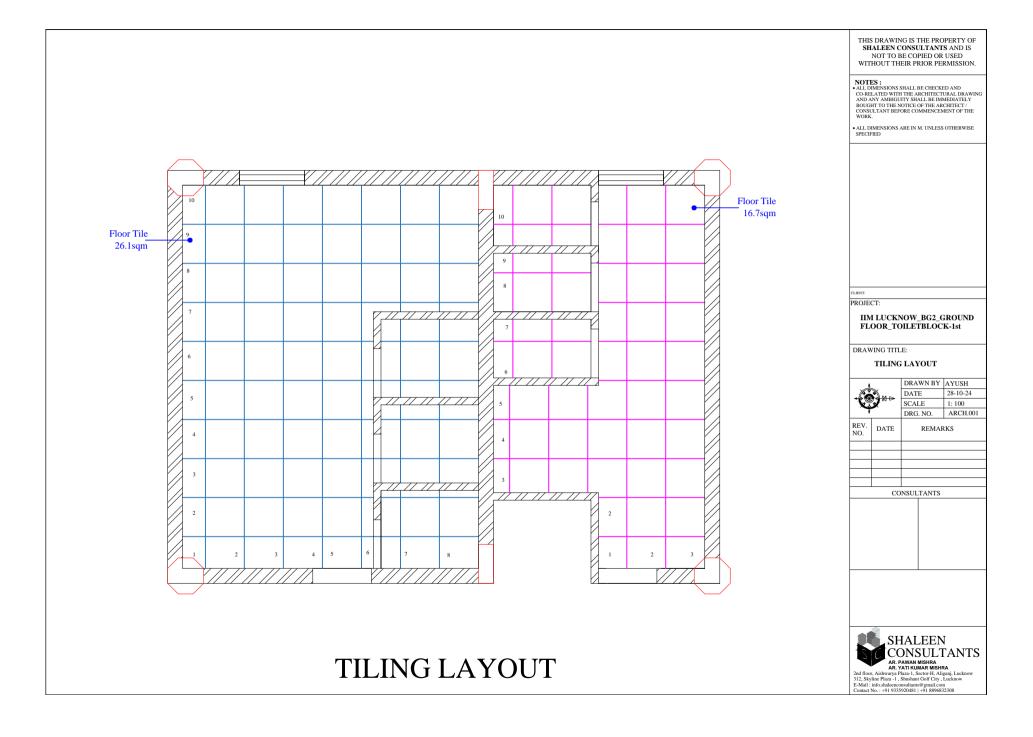

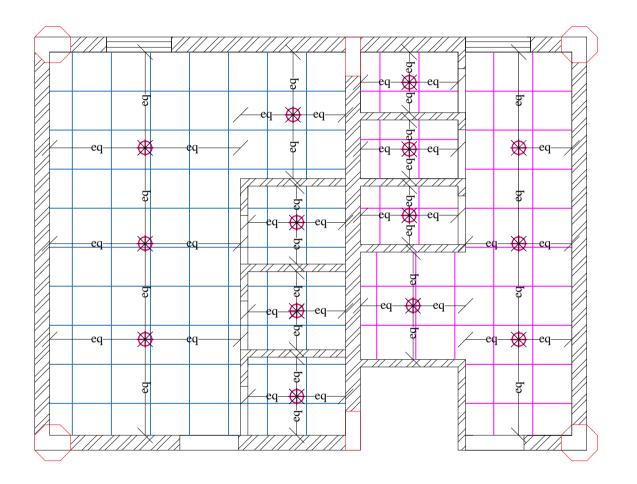

FALSE CEILING LAYOUT

THIS DRAWING IS THE PROPERTY OF SHALEEN CONSULTANTS AND IS NOT TO BE COPIED OR USED WITHOUT THEIR PRIOR PERMISSION.

NOTES:

*ALL DIMENSIONS SHALL BE CHECKED AND
CO-RELATED WITH THE ARCHITECTURAL DRAWING
AND ANY AMBIGUITY SHALL BE IMMEDIATELY
BOUGHT TO THE NOTICE OF THE ARCHITECT /
CONSULTANT BEFORE COMMENCEMENT OF THE
WORK.

ALL DIMENSIONS ARE IN M. UNLESS OTHERWISE SPECIFIED

PROJECT:


IIM LUCKNOW_BG2_GROUND FLOOR TOILETBLOCK-1st


DRAWING TITLE:


FALSE CEILING LAYOUT


	4		DRAWN BY AYUSH	
			DATE	28-10-24
			SCALE	1: 100
			DRG. NO.	ARCH.001
	REV. NO.	DATE	REMAR	RKS
		CO	NSULTANTS	




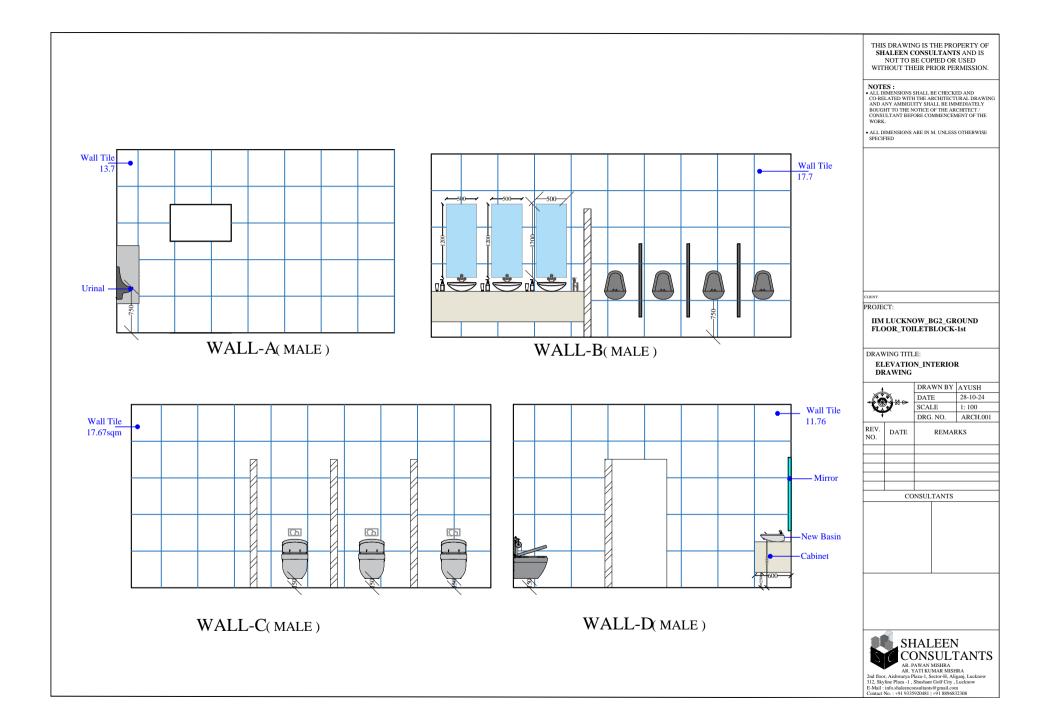


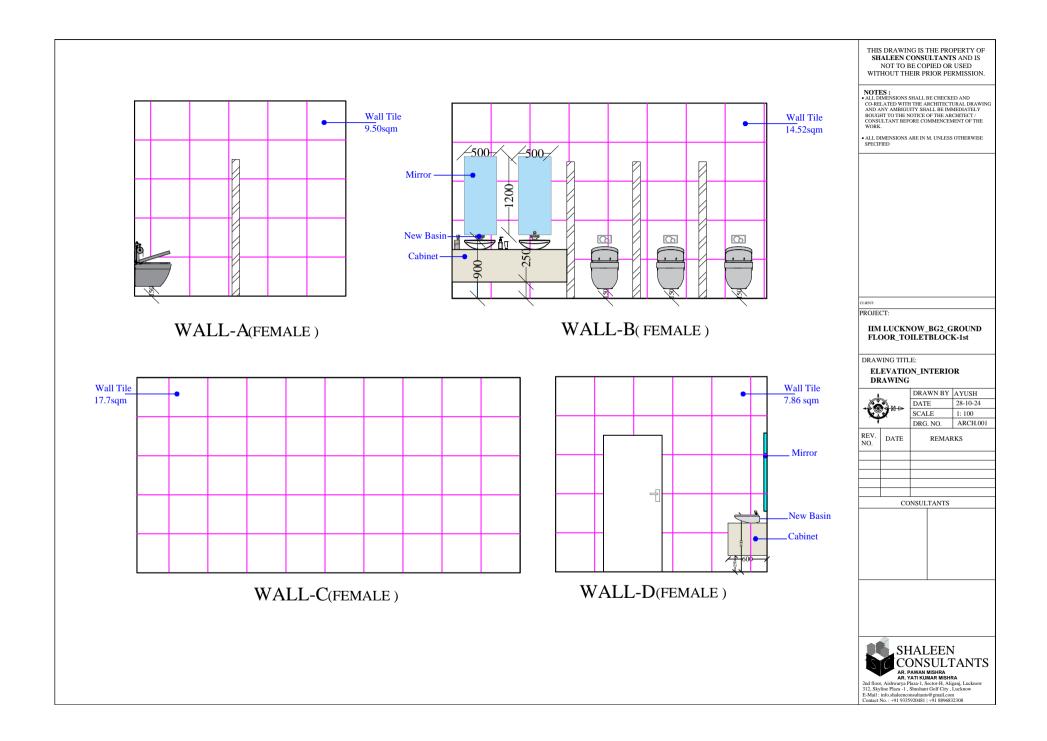

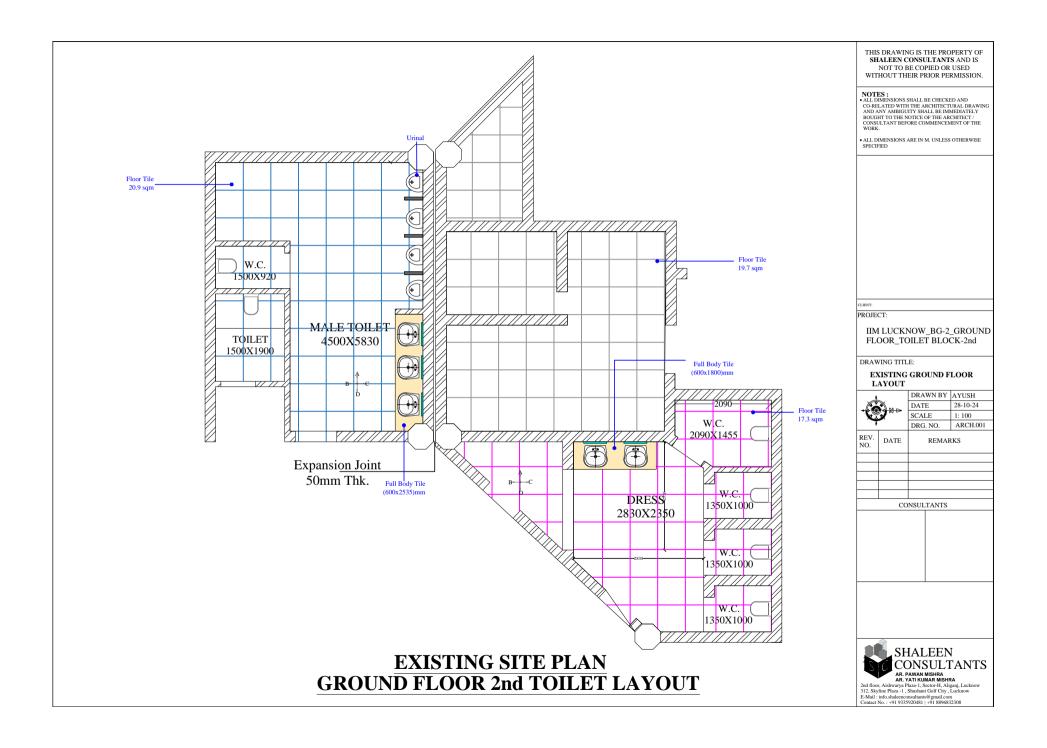

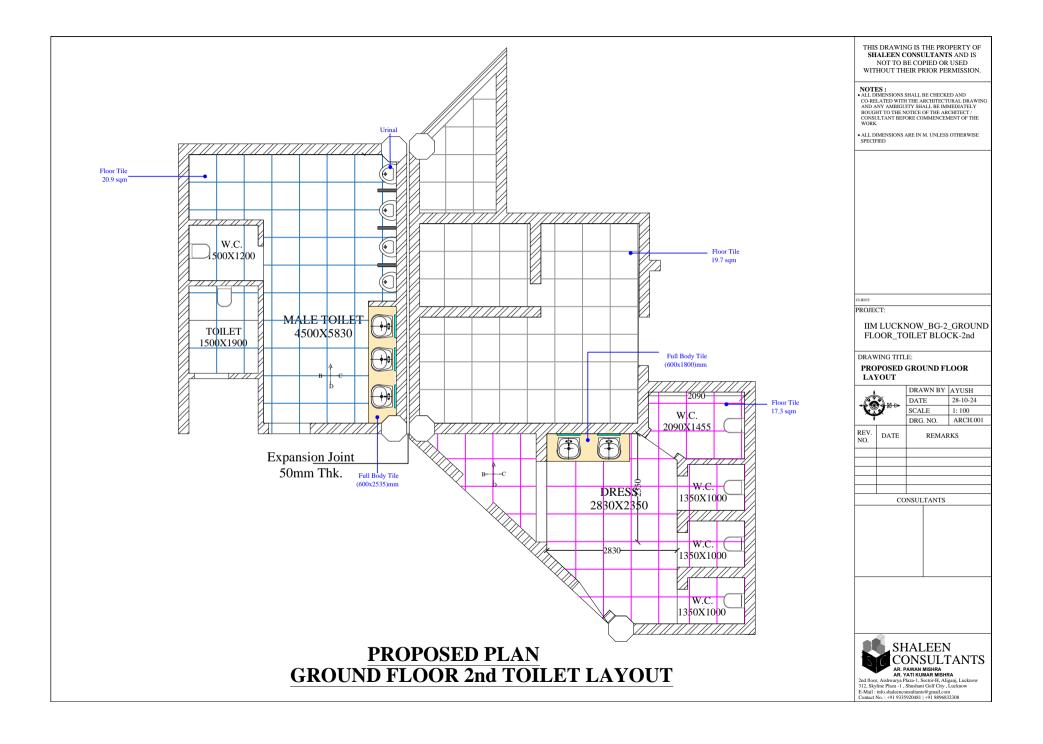

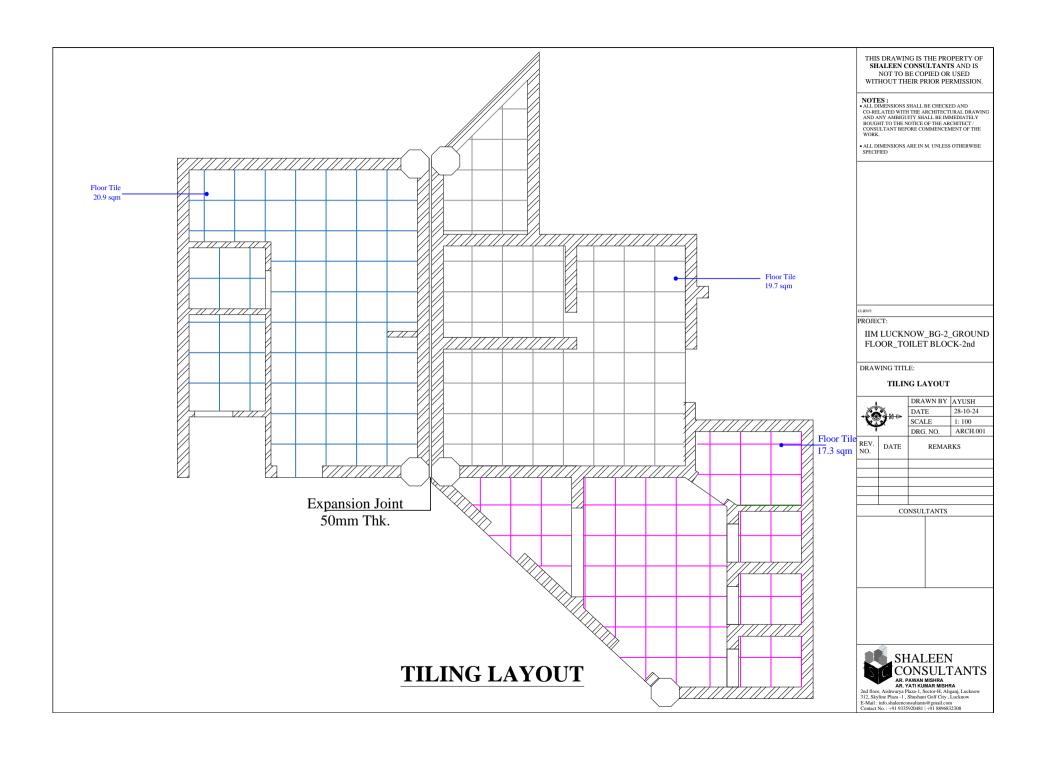

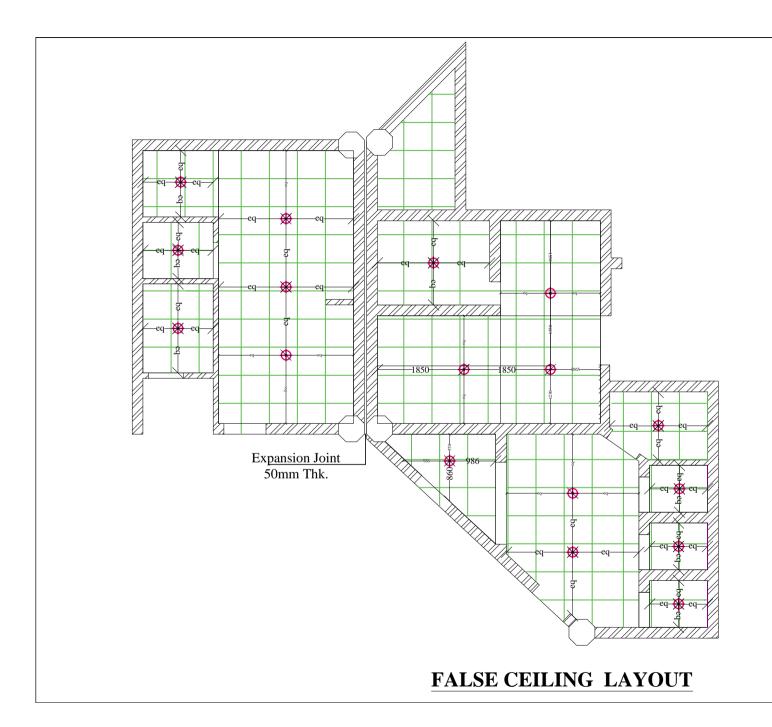

THIS DRAWING IS THE PROPERTY OF SHALEEN CONSULTANTS AND IS NOT TO BE COPIED OR USED WITHOUT THEIR PRIOR PERMISSION.

NOTES:

*ALL DIMENSIONS SHALL BE CHECKED AND
CO-RELATED WITH THE ARCHITECTURAL DRAWING
AND ANY AMBIGUITY SHALL BE IMMEDIATELY
BOUGHT TO THE NOTICE OF THE ARCHITECT /
CONSULTANT BEFORE COMMENCEMENT OF THE
WORK.

ALL DIMENSIONS ARE IN M. UNLESS OTHERWISE SPECIFIED

PROJECT:

IIM LUCKNOW_BG-2_GROUND FLOOR_TOILET BLOCK-2nd

DRAWING TITLE:

FALSE CEILING LAYOUT

±	Ι
. (Ca)	Ι
	S
Ŧ	Т

	DRAWN BY	AYUSH
	DATE	28-10-24
	SCALE	1: 100
	DRG. NO.	ARCH.001

REV. NO.	DATE	REMARKS

CONSULTANTS

SHALEEN CONSULTANTS


AR. PAWAM MISHRA


AR. YATI KUMAR MISHRA


2nd floor, Aishwayer Plazz-1, Sectoreth, Aligani, Lucknow
312. Skyline Pilzz-1 - Sunbaunt Golf City, Lucknow

E-Mail: info.hathe-consollatura (gmail com

Comtact No.: +91 9335920481 |+91 8896832308

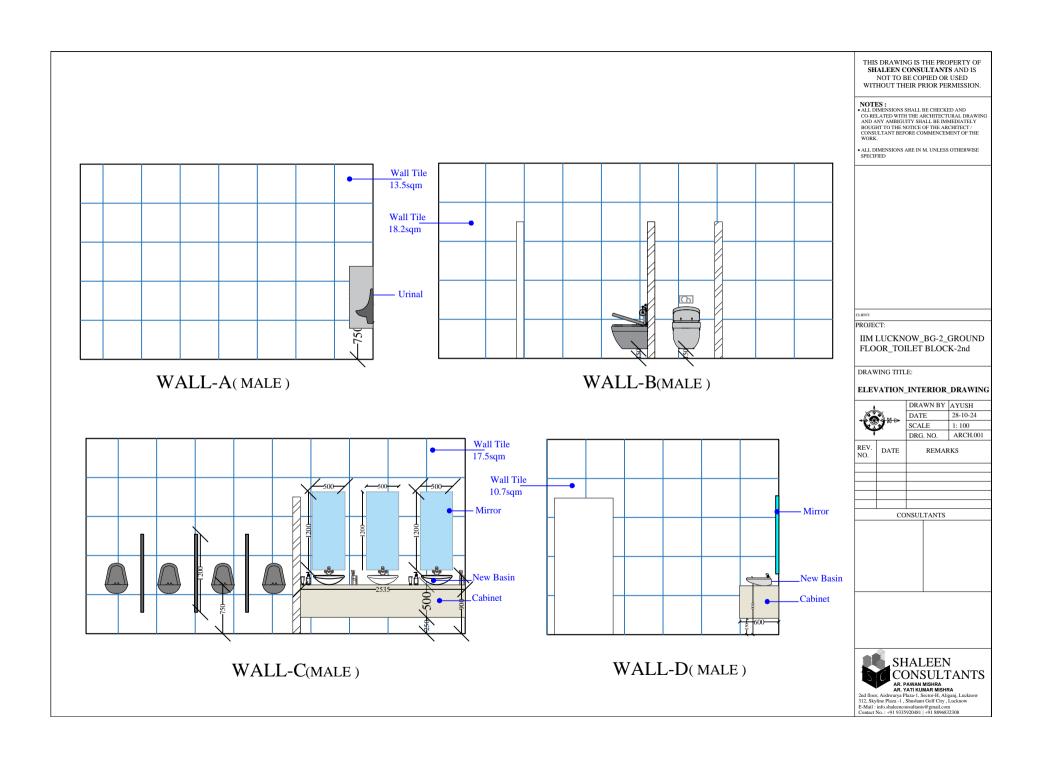

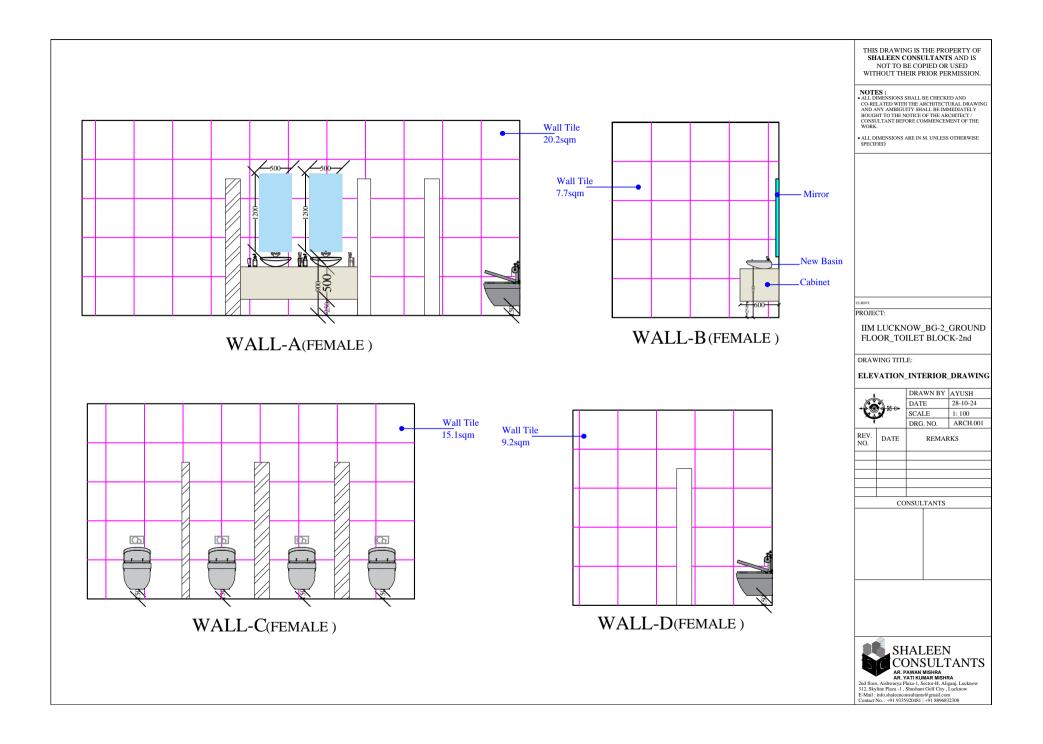

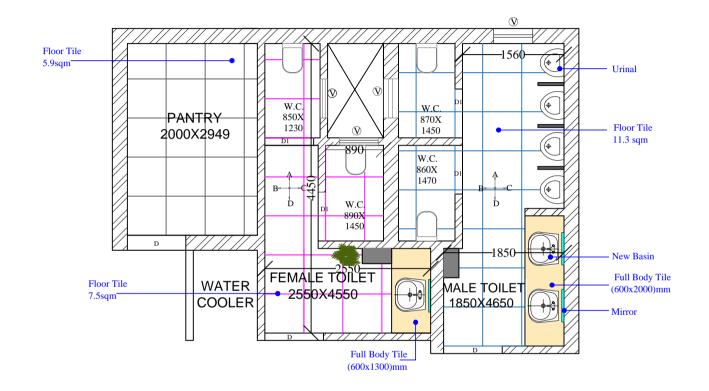

TOILET PLAN LAYOUT

THIS DRAWING IS THE PROPERTY OF SHALEEN CONSULTANTS AND IS NOT TO BE COPIED OR USED WITHOUT THEIR PRIOR PERMISSION.

NOTES:

*ALL DIMENSIONS SHALL BE CHECKED AND
CO-RELATED WITH THE ARCHITECTURAL DRAWING
AND ANY AMBIGUITY SHALL BE IMMEDIATELY
BOUGHT TO THE NOTICE OF THE ARCHITECT /
CONSULTANT BEFORE COMMENCEMENT OF THE
WORK.

• ALL DIMENSIONS ARE IN M. UNLESS OTHERWISE

PROJECT:

IIM LUCKNOW_LIBRARY_ FIRSTFLOOR_TOILET BLOCK

DRAWING TITLE:

INTERIOR WORK OF LIBRARY TOILET




REV. NO. DATE REMARKS

CONSULTANTS

SHALEEN CONSULTANTS

AR, PAWAN MISHRA
AR, YATI KUMAR MISHRA
2nd floor, Aishwaya Plaza-1, Sector-H, Aliganj, Lucknow
312, Skyline Plaza-1, Shushant Golf City, Lucknow
E-Mail: info.shaleaenconsultantie gmail.com
Contact No. 1-91 9335920481 | +91 8896832308

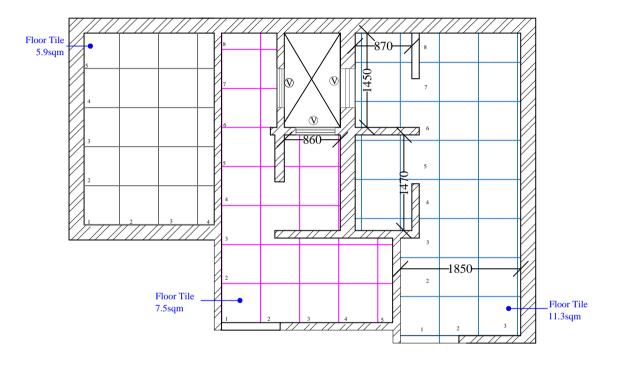

FIRST FLOOR TOILET TILING PLAN

THIS DRAWING IS THE PROPERTY OF SHALEEN CONSULTANTS AND IS NOT TO BE COPIED OR USED WITHOUT THEIR PRIOR PERMISSION.

NOTES:

*ALL DIMENSIONS SHALL BE CHECKED AND
CO-RELATED WITH THE ARCHITECTURAL DRAWING
AND ANY AMBIGUITY SHALL BE IMMEDIATELY
BOUGHT TO THE NOTICE OF THE ARCHITECT?
CONSULTANT BEFORE COMMENCEMENT OF THE
WORK.

ALL DIMENSIONS ARE IN M. UNLESS OTHERWISE SPECIFIED

PROJECT:

IIM LUCKNOW_LIBRARY_ FIRSTFLOOR_TOILET BLOCK

DRAWING TITLE:

TILING LAYOUT PLAN



DRAWN BY AYUSH DATE 26-10-24 SCALE 1: 100 DRG. NO. ARCH.001

REV. NO. REMARKS

CONSULTANTS

SHALEEN CONSULTANTS


AR. PAWAM MISHRA

AR. YATI KUMAR MISHRA

2nd floor, Aishwayer Plazz-1, Sectoreth, Aligani, Lucknow
312. Skyline Pilzz-1 - Sunbaunt Golf City, Lucknow

E-Mail: info.hathe-consollatura (gmail com

Comtact No.: +91 9335920481 |+91 8896832308

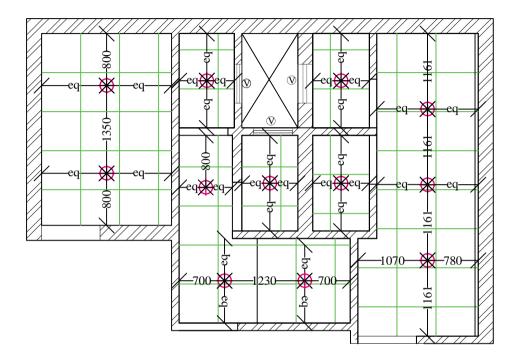

FALSE CEILING LAYOUT

THIS DRAWING IS THE PROPERTY OF SHALEEN CONSULTANTS AND IS NOT TO BE COPIED OR USED WITHOUT THEIR PRIOR PERMISSION.

NOTES:

*ALL DIMENSIONS SHALL BE CHECKED AND
CO-RELATED WITH THE ARCHITECTURAL DRAWING
AND ANY AMBIGUITY SHALL BE IMMEDIATELY
BOUGHT TO THE NOTICE OF THE ARCHITECT?
CONSULTANT BEFORE COMMENCEMENT OF THE
WORK.

ALL DIMENSIONS ARE IN M. UNLESS OTHERWISE SPECIFIED

PROJECT:

IIM LUCKNOW_LIBRARY_ FIRSTFLOOR_TOILET BLOCK

DRAWING TITLE:

FALSE CEILING LAYOUT



		DRG. NO.	AICCI1.001
REV. NO.	DATE	REMAR	tKS

CONSULTANTS

SHALEEN CONSULTANTS


AR. PAWAM MISHRA


AR. YATI KUMAR MISHRA


2nd floor, Aishwayer Plazz-1, Sectoreth, Aligani, Lucknow
312. Skyline Pilzz-1 - Sunbaunt Golf City, Lucknow


E-Mail: info.hathe-consollatura (gmail com

Comtact No.: +91 9335920481 |+91 8896832308

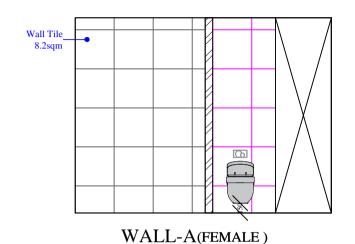

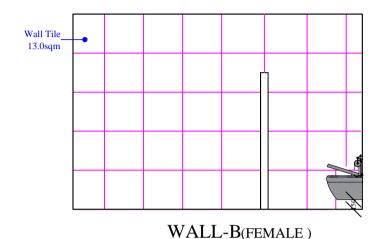

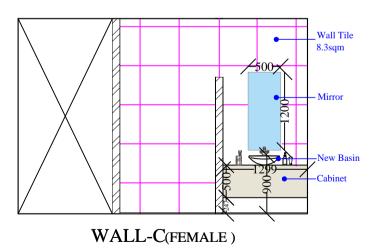

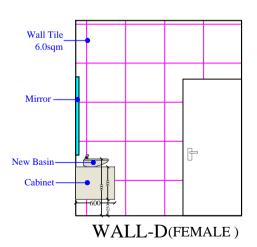

THIS DRAWING IS THE PROPERTY OF SHALEEN CONSULTANTS AND IS NOT TO BE COPIED OR USED WITHOUT THEIR PRIOR PERMISSION.

NOTES:

*ALL DIMENSIONS SHALL BE CHECKED AND
CO-RELATED WITH THE ARCHITECTURAL DRAWING
AND ANY AMBIGUITY SHALL BE IMMEDIATELY
BOUGHT TO THE NOTICE OF THE ARCHITECT /
CONSULTANT BEFORE COMMENCEMENT OF THE
WORK.

ALL DIMENSIONS ARE IN M. UNLESS OTHERWISE SPECIFIED

PROJECT:

IIM LUCKNOW_LIBRARY_ FIRSTFLOOR_TOILET BLOCK


DRAWING TITLE: ELEVATION_INTERIOR DRAWING




DRAWN BY	AYUSH
DATE	26-10-24
SCALE	1: 100
DRG NO	ARCH 001

•		DRG	. NO.	ARCH.001
REV. NO.	DATE	REMARKS		RKS
	CONSULTANTS			



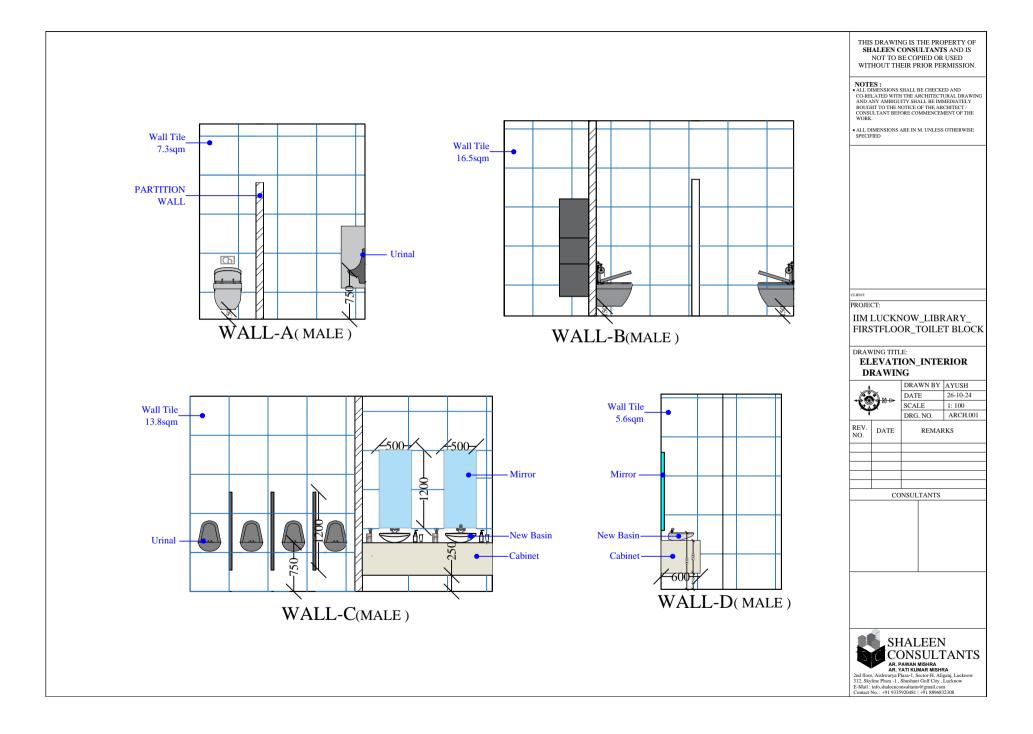

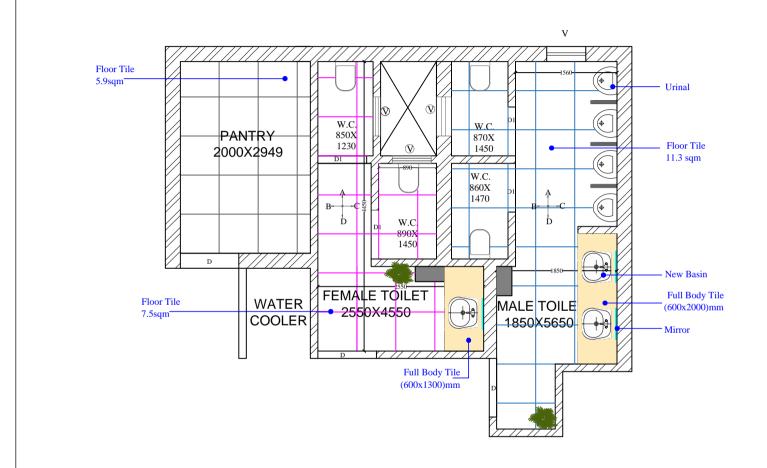

LIBRARY GROUND FLOOR TOILET

THIS DRAWING IS THE PROPERTY OF SHALEEN CONSULTANTS AND IS NOT TO BE COPIED OR USED WITHOUT THEIR PRIOR PERMISSION.

NOTES:

*ALL DIMENSIONS SHALL BE CHECKED AND
CO-RELATED WITH THE ARCHITECTURAL DRAWING
AND ANY AMBIGUITY SHALL BE IMMEDIATELY
BOUGHT TO THE NOTICE OF THE ARCHITECT /
CONSULTANT BEFORE COMMENCEMENT OF THE
WORK.

• ALL DIMENSIONS ARE IN M. UNLESS OTHERWISE

PROJECT:

IIM LUCKNOW LIBRARY GROUNDFLOOR TOILET BLOCK

DRAWING TITLE:


INTERIOR WORK OF LIBRARY TOILET

26-10-24

₩÷	DRAWN BY	AYUSH	
	3 ~ ~ 6	DATE	26-10-24
	3	SCALE	1: 100
	-	DRG. NO.	ARCH.0

O. ARCH.001 REV. NO. DATE REMARKS CONSULTANTS

SHALEEN CONSULTANTS
AR PAWAM MISHRA
2nd floor, Aishwaya Plaza-1, Sextor-H, Aligani, Lucknow
12, Skylin Plaza-1, Shushum GOT (Gry, Lucknow
E-Mail: info.shaleenconsultant@gmail.com
Counter No. -91 9355592681 | 193 880882308

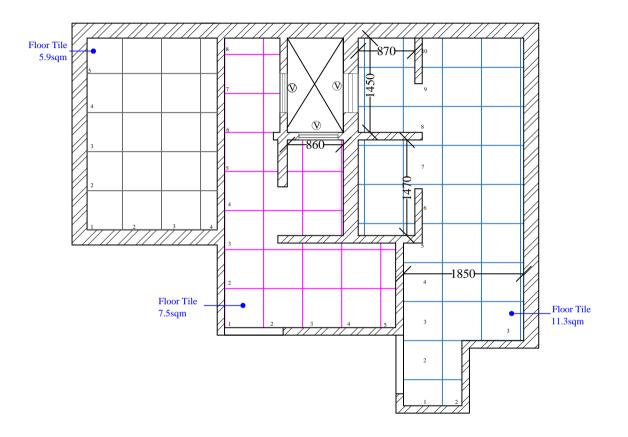

LIBRARY TOILET TILE FLOOR

THIS DRAWING IS THE PROPERTY OF SHALEEN CONSULTANTS AND IS NOT TO BE COPIED OR USED WITHOUT THEIR PRIOR PERMISSION.

NOTES:

*ALL DIMENSIONS SHALL BE CHECKED AND
CO-RELATED WITH THE ARCHITECTURAL DRAWING
AND ANY AMBIGUITY SHALL BE IMMEDIATELY
BOUGHT TO THE NOTICE OF THE ARCHITECT?
CONSULTANT BEFORE COMMENCEMENT OF THE
WORK.

• ALL DIMENSIONS ARE IN M. UNLESS OTHERWISE SPECIFIED

PROJECT:

IIM LUCKNOW_LIBRARY_ GROUNDFLOOR_TOILET BLOCK


DRAWING TITLE:

TILING LAYOUT DRAWING

1	DRAWN BY	AYUSH
N->	DATE	26-10-24
	SCALE	1: 100
T	DRG. NO.	ARCH.00

REV. NO.	DATE	REMARKS		
CONSULTANTS				
		1		

SHALEEN
CONSULTANTS
AR, PAWAN MISHRA
AR, YATI KUMAR MISHRA
2nd floor, Aichwaye Pizzz-1, Secure H., Aliganj, Lucknow
312, Skyline Pizza-1, Subsubant Golf City, Lucknow
E-Mal; infini Alaheconosultans (@panil com
Comact No.: +91 9335920481 |+91 8896832308

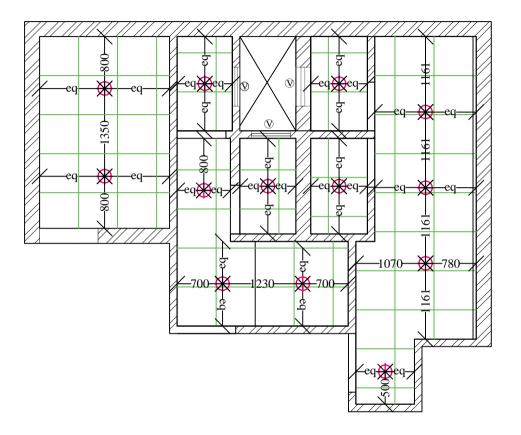

LIBRARY TOILET FALSE CEILING

THIS DRAWING IS THE PROPERTY OF SHALEEN CONSULTANTS AND IS NOT TO BE COPIED OR USED WITHOUT THEIR PRIOR PERMISSION.

NOTES:

*ALL DIMENSIONS SHALL BE CHECKED AND
CO-RELATED WITH THE ARCHITECTURAL DRAWING
AND ANY AMBIGUITY SHALL BE IMMEDIATELY
BOUGHT TO THE NOTICE OF THE ARCHITECT?
CONSULTANT BEFORE COMMENCEMENT OF THE
WORK.

ALL DIMENSIONS ARE IN M. UNLESS OTHERWISE SPECIFIED

PROJECT:

IIM LUCKNOW_LIBRARY_ GROUNDFLOOR TOILET BLOCK


DRAWING TITLE:


FALSE CEILING LAYOUT


₩÷		DRAWN BY	AYUSH
		DATE	26-10-24
		SCALE	1: 100
		DRG. NO.	ARCH.00
REV.	DATE	PEMAI	oks .


CONSULTANTS

SHALEEN CONSULTANTS
AC. PAWADA MISHRA
AF, YATI KUMBAR MISHRA
2nd floor, Aishwaya Pitza-1, Sector-H, Aligani, Lucknow
312. Skyline Pitza-1, Shushant GOT (City, Lucknow
E-Mai; info.shabeenconsultanto@gmail.com
Connact No.: =919.355292841 | 1918.880832308

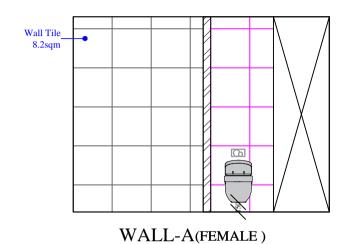

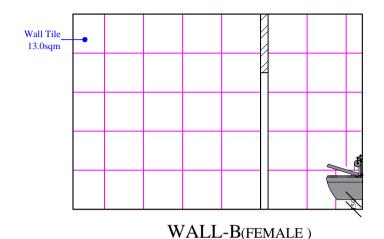

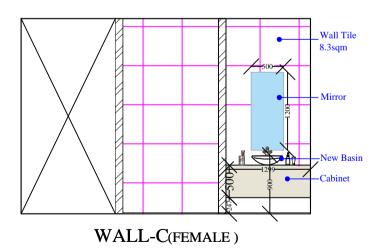

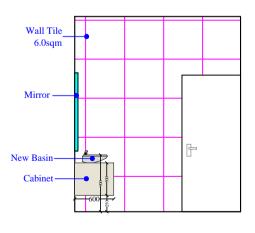

WALL-D(FEMALE)

THIS DRAWING IS THE PROPERTY OF SHALEEN CONSULTANTS AND IS NOT TO BE COPIED OR USED WITHOUT THEIR PRIOR PERMISSION.

NOTES:

*ALL DIMENSIONS SHALL BE CHECKED AND
CO-RELATED WITH THE ARCHITECTURAL DRAWING
AND ANY AMBIGUITY SHALL BE IMMEDIATELY
BOUGHT TO THE NOTICE OF THE ARCHITECT /
CONSULTANT BEFORE COMMENCEMENT OF THE
WORK.

ALL DIMENSIONS ARE IN M. UNLESS OTHERWISE SPECIFIED

PROJECT:

IIM LUCKNOW_LIBRARY_ GROUNDFLOOR_TOILET BLOCK


DRAWING TITLE: ELEVATION_INTERIOR DRAWING





DRAWN BY	AYUSH	
DATE	26-10-24	
SCALE	1: 100	
DRG. NO.	ARCH.001	

		DRG	. NO.	ARCH.001
REV. NO.	DATE		REMAR	RKS
	CO	NSUL	TANTS	



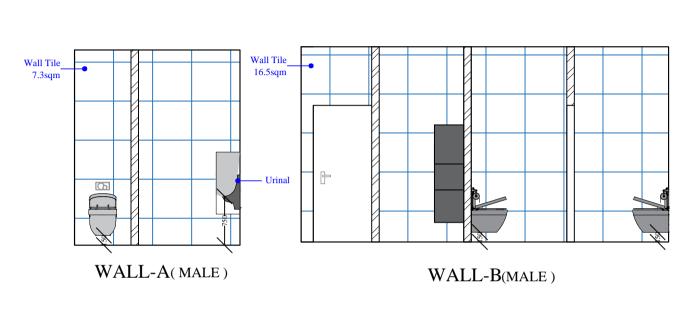

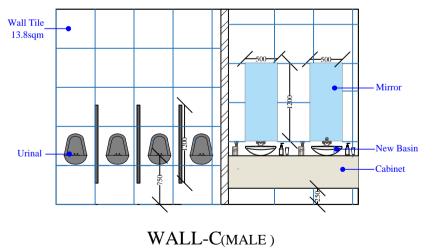

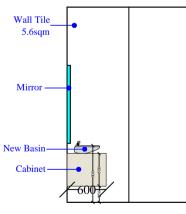

 $WALL\text{-}D(\,\text{MALE}\,)$

THIS DRAWING IS THE PROPERTY OF SHALEEN CONSULTANTS AND IS NOT TO BE COPIED OR USED WITHOUT THEIR PRIOR PERMISSION.

NOTES:

*ALL DIMENSIONS SHALL BE CHECKED AND
CO-RELATED WITH THE ARCHITECTURAL DRAWING
AND ANY AMBIGUITY SHALL BE IMMEDIATELY
BOUGHT TO THE NOTICE OF THE ARCHITECT/
CONSULTANT BEFORE COMMENCEMENT OF THE
WORK.

ALL DIMENSIONS ARE IN M. UNLESS OTHERWISE SPECIFIED

PROJECT:

IIM LUCKNOW_LIBRARY_ GROUNDFLOOR_TOILET BLOCK


DRAWING TITLE: ELEVATION_INTERIOR DRAWING


|--|--|

	DRAWN BY	AYUSH
~	DATE	26-10-24
_	SCALE	1: 100
	DRG NO	ARCH.001

7		DRG	. NO.	ARCH.001
REV. NO.	DATE	REMARKS		RKS
	CO	NSUL	TANTS	




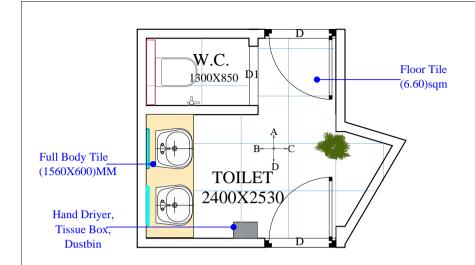

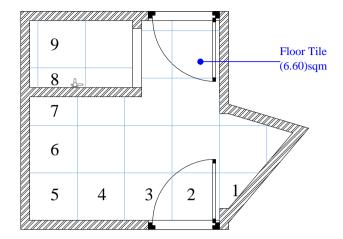

UPPER GROUND FLOOR PLAN C.A.O. OFFICE

TILING PLAN

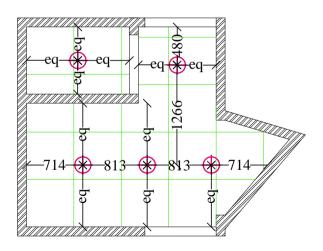

FALSE CEILING PLAN

THIS DRAWING IS THE PROPERTY OF SHALEEN CONSULTANTS AND IS NOT TO BE COPIED OR USED WITHOUT THEIR PRIOR PERMISSION.

NOTES:
• ALL DIMENSIONS SHALL BE CHECKED AND CO-RELATED WITH THE ARCHITECTURAL DRAWING AND ANY AMBIGUITY SHALL BE IMMEDIATELY BOUGHT TO THE NOTICE OF THE ARCHITECT / CONSULTANT BEFORE COMMENCEMENT OF THE WORK.

ALL DIMENSIONS ARE IN M. UNLESS OTHERWISE

CLIENT:

PROJECT:

IIM _LUCKNOW_SAMADHAN BUILDING_CAO OFFICE_ TOILETBLOCK

DRAWING TITLE:


UPPER GROUND FLOOR TOILET_BLOCK_LAYOUT_PLAN


N+	DRAWN BY	SUDHANSHU	
	<i>M</i> ~ ~ <i>∞</i>	DATE	29-10-2024
	SCALE	1: 100	
7		DRG. NO.	ARCH.001
D. E. I.			


DATE REMARKS CONSULTANTS




2nd floor, Aishwarya Plaza-1, Sector-H, Aliganj, Lucknow 312, Skyline Plaza-1, Shushant Golf City, Lucknow E-Mail: info.shaleenconsultants@gmail.com Contact No.: +91 9335920481 | +91 8896832308

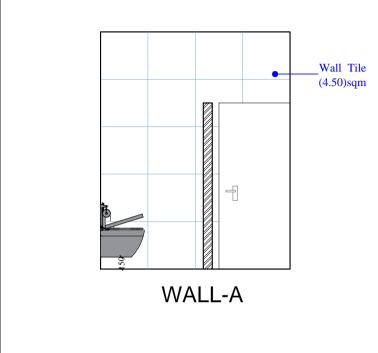

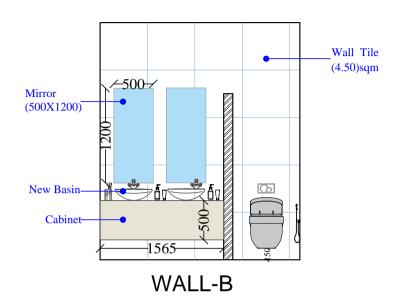

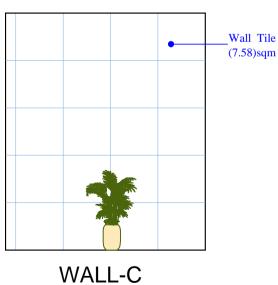

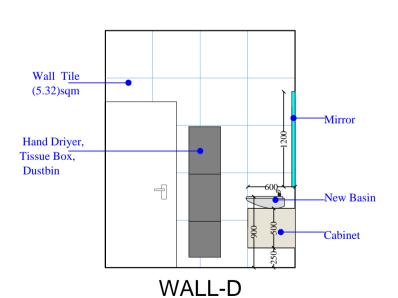

THIS DRAWING IS THE PROPERTY OF SHALEEN CONSULTANTS AND IS NOT TO BE COPIED OR USED WITHOUT THEIR PRIOR PERMISSION.

NOTES:

• ALL DIMENSIONS SHALL BE CHECKED AND CO-RELATED WITH THE ARCHITECTURAL DRAWING AND ANY AMBIGUITY SHALL BE IMMEDIATELY BOUGHT TO THE NOTICE OF THE ARCHITECT / CONSULTANT BEFORE COMMENCEMENT OF THE WORK.

ALL DIMENSIONS ARE IN M. UNLESS OTHERWISE SPECIFIED

CLIENT:

PROJECT:

IIM _LUCKNOW_SAMADHAN BUILDING_CAO OFFICE_ TOILETBLOCK

DRAWING TITLE:

ELEVATION_INTERIOR DRAWING

29-10-2024


1: 100



*		DRG	. NO.	ARCH.001
REV. NO.	DATE		REMA	RKS
	CO	NSUL	TANTS	



2nd floor, Aishwarya Plaza-1, Sector-H, Aliganj, Lucknow 312, Skyline Plaza-1, Shushant Golf City, Lucknow E-Mail: info.shaleenconsultants@gmail.com Contact No.: +91 9335920481 | +91 8896832308

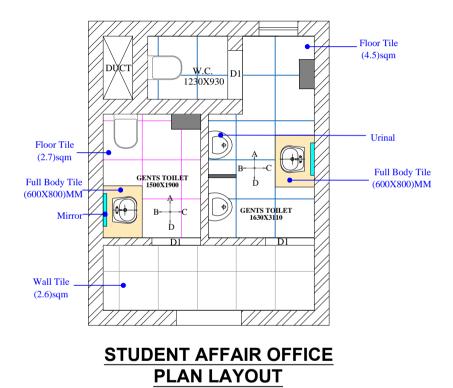

THIS DRAWING IS THE PROPERTY OF SHALEEN CONSULTANTS AND IS NOT TO BE COPIED OR USED WITHOUT THEIR PRIOR PERMISSION.

NOTES:

*ALL DIMENSIONS SHALL BE CHECKED AND
CO-RELATED WITH THE ARCHITECTURAL DRAWING
AND ANY AMBIGUITY SHALL BE IMMEDIATELY
BOUGHT TO THE NOTICE OF THE ARCHITECT /
CONSULTANT BEFORE COMMENCEMENT OF THE
WORK.

ALL DIMENSIONS ARE IN M. UNLESS OTHERWISE SPECIFIED

PROJECT:

IIM LUCKNOW_STUDENT AFFAIR OFFICE_TOILET BLOCK

DRAWING TITLE:


PLAN LAYOUT




REV. NO. DATE REMARKS

CONSULTANTS

SHALEEN CONSULTANTS
AC. PAWADA MISHRA
AF, YATI KUMBAR MISHRA
2nd floor, Aishwaya Pitza-1, Sector-H, Aligani, Lucknow
312. Skyline Pitza-1, Shushant GOT (City, Lucknow
E-Mai; info.shabeenconsultanto@gmail.com
Connact No.: =919.355292841 | 1918.880832308

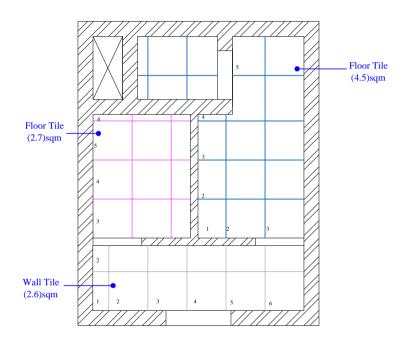

TILING LAYOUT

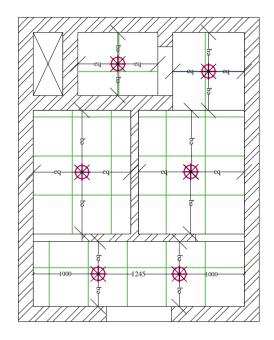

FALSE CEILING LAYOUT

THIS DRAWING IS THE PROPERTY OF SHALEEN CONSULTANTS AND IS NOT TO BE COPIED OR USED WITHOUT THEIR PRIOR PERMISSION.

NOTES:

*ALL DIMENSIONS SHALL BE CHECKED AND
CO-RELATED WITH THE ARCHITECTURAL DRAWING
AND ANY AMBIGUITY SHALL BE IMMEDIATELY
BOUGHT TO THE NOTICE OF THE ARCHITECT?
CONSULTANT BEFORE COMMENCEMENT OF THE
WORK.

• ALL DIMENSIONS ARE IN M. UNLESS OTHERWISE SPECIFIED

PROJECT:

IIM LUCKNOW_STUDENT AFFAIR OFFICE_TOILET BLOCK

DRAWING TITLE:

TILING LAYOUT,FALSE CEILING LAYOUT


~


DRAWN BY	AYUSH
DATE	28-10-24
SCALE	1: 100
DRG NO	ARCH.001


		DKG. NO.	AICCI1.001
REV. NO.	DATE	REMAR	RKS

CONSULTANTS

SHALEEN
CONSULTANTS
AR, PAWAN MISHRA
AR, YATI KUMAR MISHRA
2nd floor, Aichwaye Pizzz-1, Secure H., Aliganj, Lucknow
312, Skyline Pizza-1, Subsubant Golf City, Lucknow
E-Mal; infini Alaheconosultans (@panil com
Comact No.: +91 9335920481 |+91 8896832308

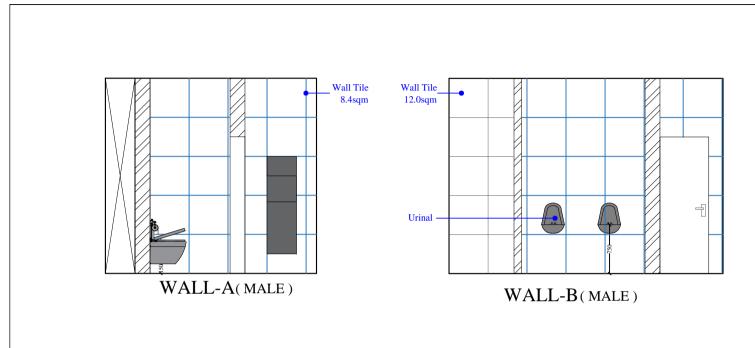

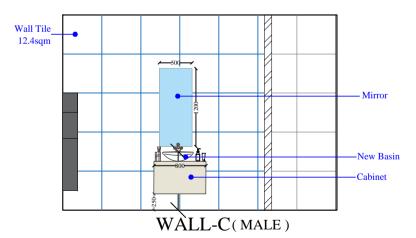

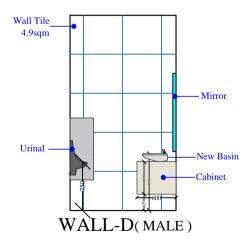

THIS DRAWING IS THE PROPERTY OF SHALEEN CONSULTANTS AND IS NOT TO BE COPIED OR USED WITHOUT THEIR PRIOR PERMISSION.

NOTES:

*ALL DIMENSIONS SHALL BE CHECKED AND
CO-RELATED WITH THE ARCHITECTURAL DRAWING
AND ANY AMBIGUITY SHALL BE IMMEDIATELY
BOUGHT TO THE NOTICE OF THE ARCHITECT /
CONSULTANT BEFORE COMMENCEMENT OF THE
WORK.

 
ALL DIMENSIONS ARE IN M. UNLESS OTHERWISE SPECIFIED

PROJECT:

IIM LUCKNOW_ STUDENT AFFAIR OFFICE_ TOILET BLOCK

DRAWING TITLE:


ELEVATION INTERIOR DRAWING





REV. NO. DATE REMARKS

CONSULTANTS

SHALEEN
CONSULTANTS
AR PAWAN MISHRA
AR YATI KUMAR MISHRA
2nd floor, Asilwaya Pilaz-1, Secon-H, Aliganji, Lucknow
312, Skyline Plaza-1, Sunsham Golf City, Lucknow
E-Mai: info. Saleconosultants @gmail.com
Commet No.: +91 9335920481 |+91 8896832308

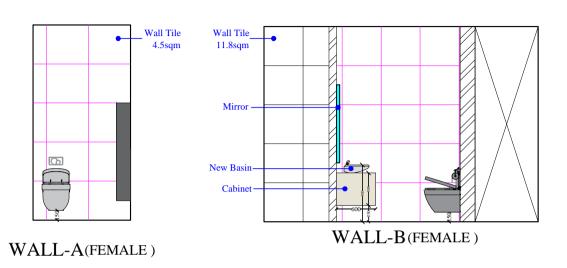

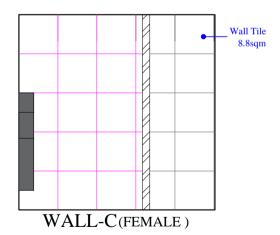

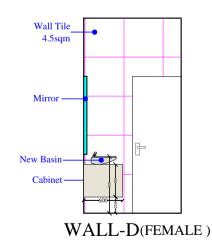

THIS DRAWING IS THE PROPERTY OF SHALEEN CONSULTANTS AND IS NOT TO BE COPIED OR USED WITHOUT THEIR PRIOR PERMISSION.

NOTES:

*ALL DIMENSIONS SHALL BE CHECKED AND
CO-RELATED WITH THE ARCHITECTURAL DRAWING
AND ANY AMBIGUITY SHALL BE IMMEDIATELY
BOUGHT TO THE NOTICE OF THE ARCHITECT /
CONSULTANT BEFORE COMMENCEMENT OF THE
WORK.

ALL DIMENSIONS ARE IN M. UNLESS OTHERWISE SPECIFIED

PROJECT:

IIM LUCKNOW_STUDENT AFFAIR OFFICE _TOILET BLOCK

DRAWING TITLE:

ELEVATION _INTERIOR DRAWING




	DRAWN BY	AYUSH
→	DATE	28-10-24
	SCALE	1: 100
	DRG. NO.	ARCH.001


REV. NO.	DATE	REMARKS	
	CONCLUTANTE		

CONSULTANTS


SHALEEN
CONSULTANTS
AR, PAWAN MISHRA
AR, YATI KUMAR MISHRA
2nd floor, Aichwaye Pizzz-1, Secure H., Aliganj, Lucknow
312, Skyline Pizza-1, Subsubant Golf City, Lucknow
E-Mal; infini Alaheconosultans (@panil com
Comact No.: +91 9335920481 |+91 8896832308

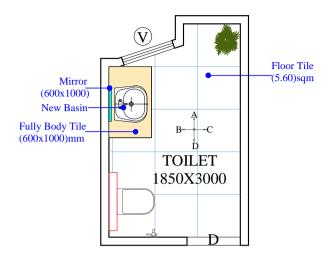

FIRST FLOOR CHAIRMAN BOARD TOILET

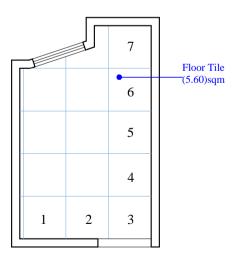



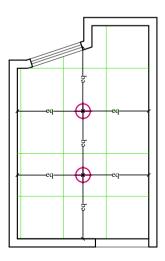

FALSE CEILING PLAN

THIS DRAWING IS THE PROPERTY OF SHALEEN CONSULTANTS AND IS NOT TO BE COPIED OR USED WITHOUT THEIR PRIOR PERMISSION.

NOTES:

• ALL DIMENSIONS SHALL BE CHECKED AND
CO-RELATED WITH THE ARCHITECTURAL DRAWING
AND ANY AMBIGUITY SHALL BE IMMEDIATELY
BOUGHT TO THE NOTICE OF THE ARCHITECT / CONSULTANT BEFORE COMMENCEMENT OF THE WORK.

ALL DIMENSIONS ARE IN M. UNLESS OTHERWISE SPECIFIED

CLIENT:

PROJECT:

IIM _LUCKNOW_SAMADHAN BUILDING_CHAIRMAN BOARD_ TOILETBLOCK

DRAWING TITLE:

FIRSTFLOOR_PLAN,TILING, FALSE CEILING LAYOUT PLAN




	DRAWN BY	SUDHANSH
	DATE	29-10-2024
-	SCALE	1: 100
	DRG. NO.	ARCH.001

REV. NO.	DATE	1	REMAR	KS	
CONSULTANT					



E-Mail: info.shaleenconsultants@gmail.com Contact No.: +91 9335920481 | +91 8896832308

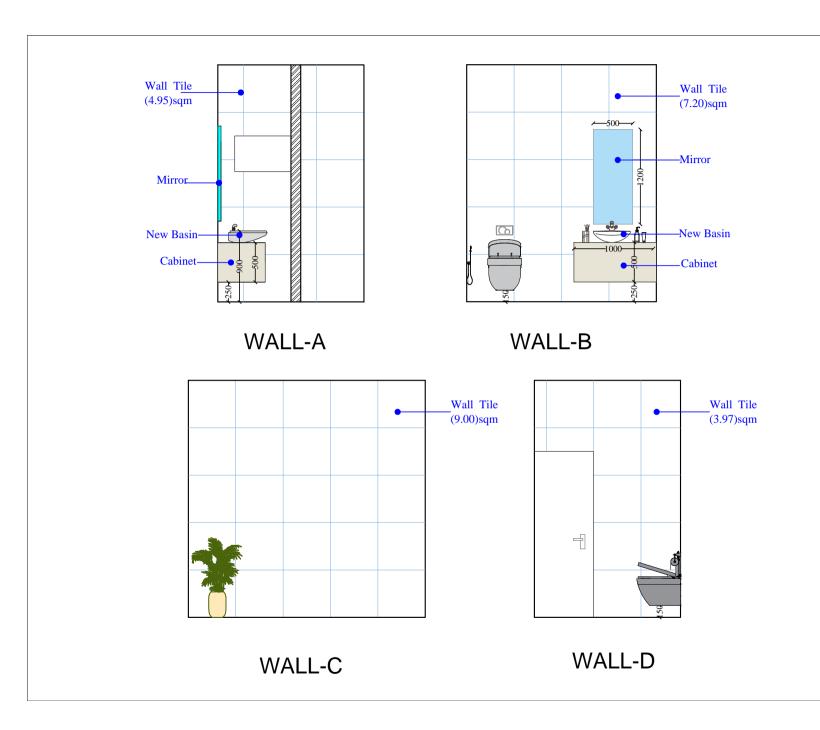

THIS DRAWING IS THE PROPERTY OF SHALEEN CONSULTANTS AND IS NOT TO BE COPIED OR USED WITHOUT THEIR PRIOR PERMISSION.

NOTES:

• ALL DIMENSIONS SHALL BE CHECKED AND CO-RELATED WITH THE ARCHITECTURAL DRAWING AND ANY AMBIGUITY SHALL BE IMMEDIATELY BOUGHT TO THE NOTICE OF THE ARCHITECT/ CONSULTANT BEFORE COMMENCEMENT OF THE WORK.

ALL DIMENSIONS ARE IN M. UNLESS OTHERWISE SPECIFIED

CLIENT:

PROJECT:

IIM _LUCKNOW_SAMADHAN BUILDING CHAIRMAN BOARD TOILETBLOCK

DRAWING TITLE:

ELEVATION_INTERIOR DRAWING





>	DRAWN BY	SUDHANSH
	DATE	29-10-2024
	SCALE	1: 100
	DRG NO	ARCH 001


· '		DKO	. NO.	ARCH.001			
REV. NO.	DATE		REMARKS				
	CONSULTANTS						




AR, PAWAN MISHRA
AR, YATI KUMAR MISHRA
2nd floor, Aishwaya Plaza-1, Sector-H, Aliganj, Lucknow
312, Skyline Plaza-1, Shushant Golf City, Lucknow
E-Mail: info. shaleenconsultans-8@ mail. com
Contact No.: +91 9335920481 | +91 8896832308

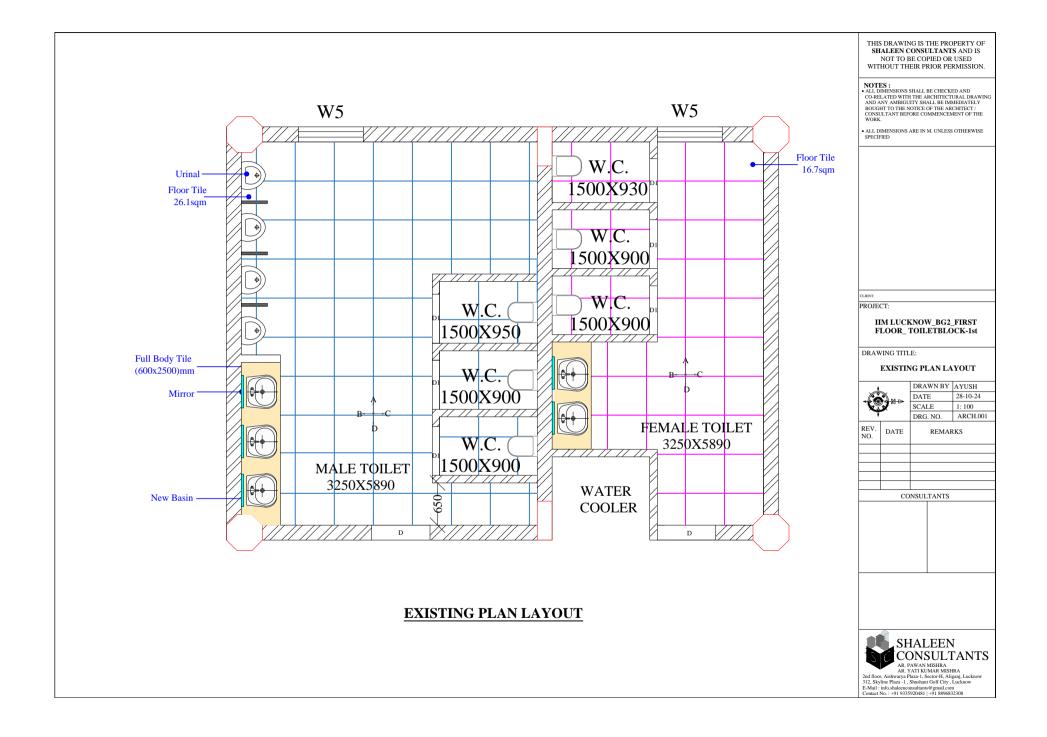

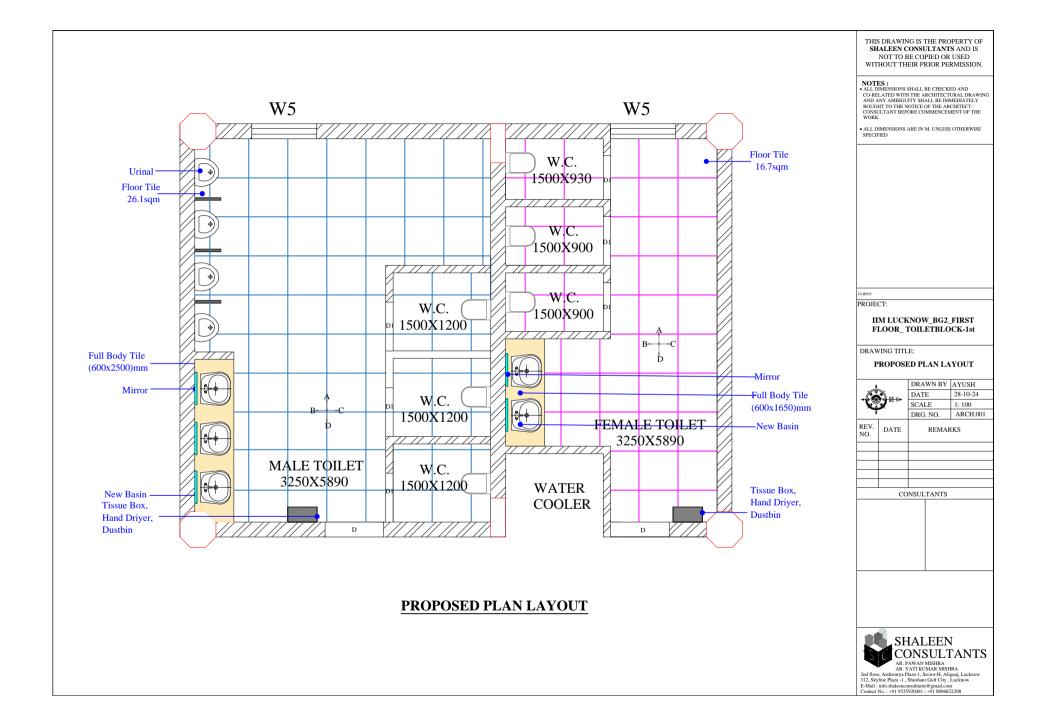

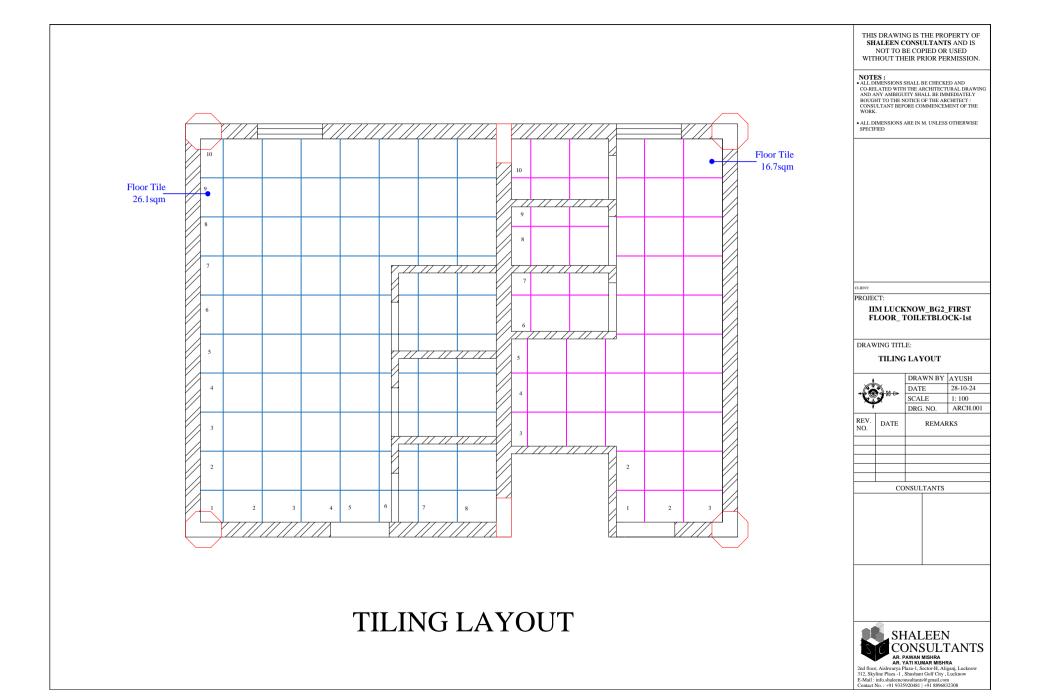

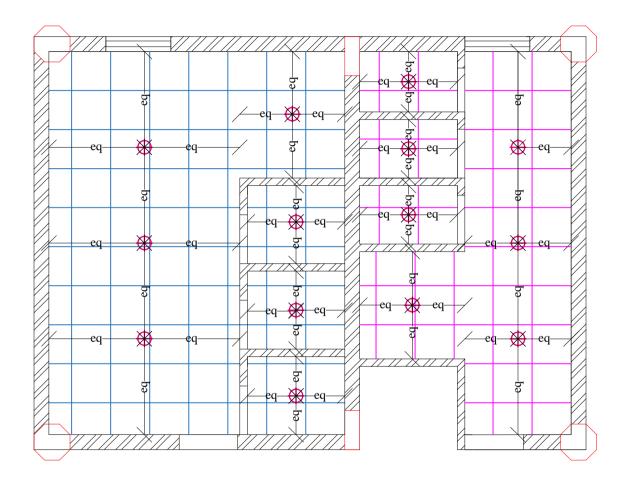

FALSE CEILING LAYOUT

THIS DRAWING IS THE PROPERTY OF SHALEEN CONSULTANTS AND IS NOT TO BE COPIED OR USED WITHOUT THEIR PRIOR PERMISSION.

NOTES:

*ALL DIMENSIONS SHALL BE CHECKED AND
CO-RELATED WITH THE ARCHITECTURAL DRAWING
AND ANY AMBIGUITY SHALL BE IMMEDIATELY
BOUGHT TO THE NOTICE OF THE ARCHITECT /
CONSULTANT BEFORE COMMENCEMENT OF THE
WORK.

ALL DIMENSIONS ARE IN M. UNLESS OTHERWISE SPECIFIED

PROJECT:

IIM LUCKNOW_BG2_FIRST FLOOR TOILETBLOCK-1st

DRAWING TITLE:


FALSE CEILING LAYOUT


±	DRAWN BY	AYUSH
- CON 101 ~	DATE	28-10-24
	SCALE	1: 100
Ŧ	DRG. NO.	ARCH.


REV. NO.	DATE	REMARKS		


CONSULTANTS

SHALEEN CONSULTANTS
AC. PAWADA MISHRA
AF, YATI KUMBAR MISHRA
2nd floor, Aishwaya Pitza-1, Sector-H, Aligani, Lucknow
312. Skyline Pitza-1, Shushant GOT (City, Lucknow
E-Mai; info.shabeenconsultanto@gmail.com
Connact No.: =919.355292841 | 1918.880832308

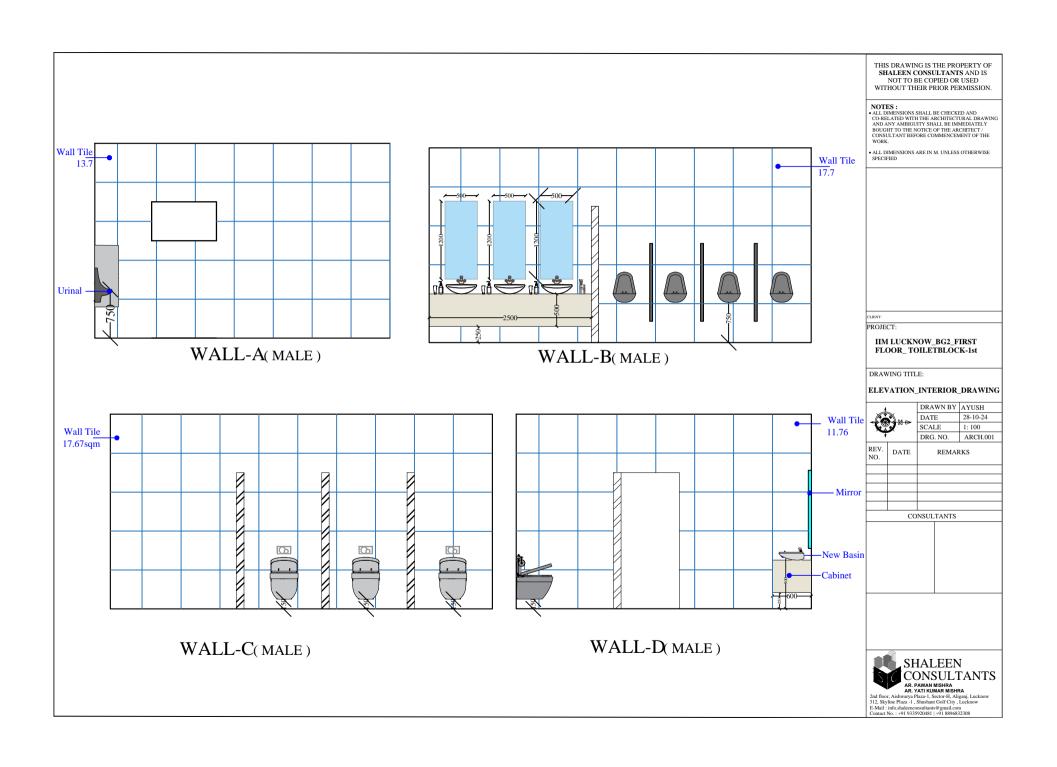

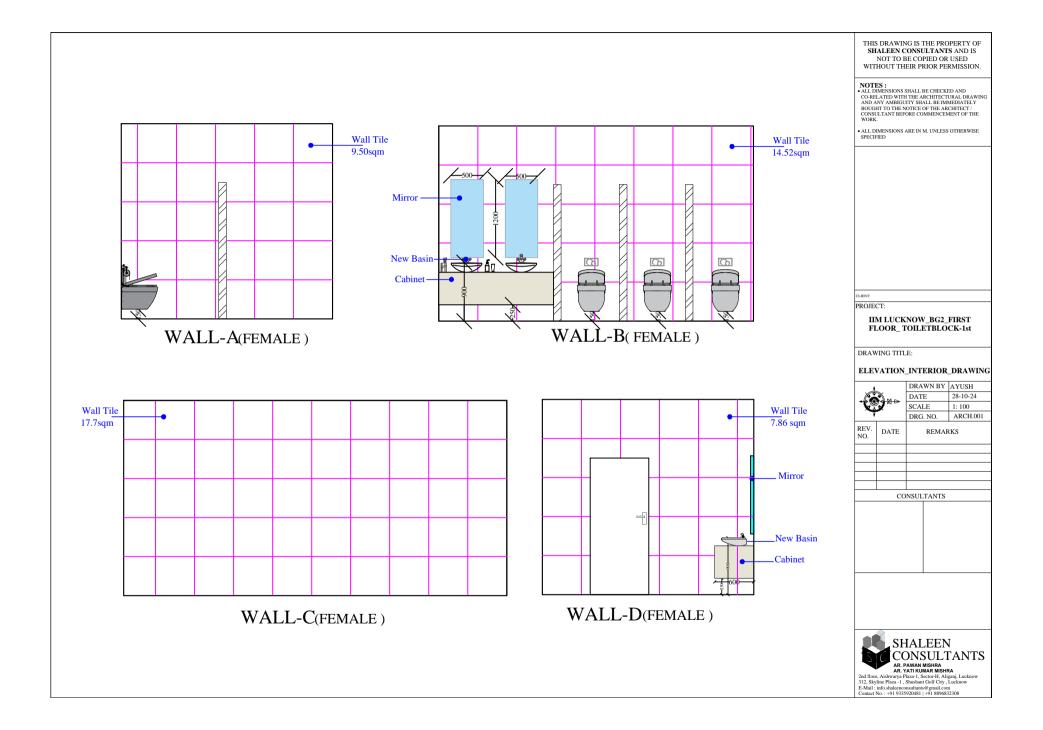

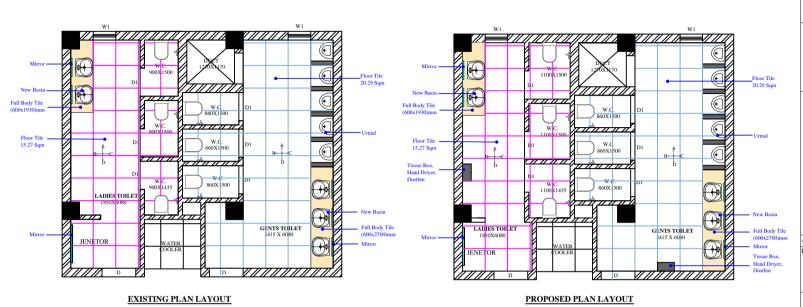

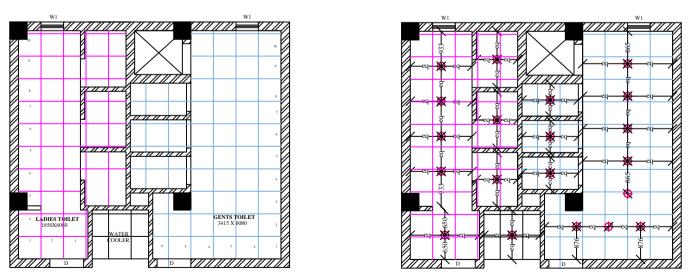

TILING LAYOUT

FALSE CEILING LAYOUT

THIS DRAWING IS THE PROPERTY OF SHALEEN CONSULTANTS AND IS NOT TO BE COPIED OR USED WITHOUT THEIR PRIOR PERMISSION.

NOTES:

• ALL DIMENSIONS SHALL BE CHECKED AND CO-RELATED WITH THE ARCHITECTURAL DRAWING AND ANY AMBIGUITY SHALL BE IMMEDIATELY BOUGHT TO THE NOTICE OF THE ARCHITECT / CONSULTANT BEFORE COMMENCEMENT OF THE WORK.

ALL DIMENSIONS ARE IN M. UNLESS OTHERWISE

PROJECT:

IIM LUCKNOW_BG-1_GROUNDFLOOR_ TOILET BLOCK-1st

DRAWING TITLE: GROUND FLOOR PLAN TILING LAYOUT_FALSE CEILING LAYOUT

DRAWING

1	DRAWN BY	AJEET
. CON 10 ~	DATE	28-10-24
	SCALE	1: 100
_		

7		DRG. NO. ARCH.001		
REV. NO.			REMARKS	
CONSULTANTS				
			l	



2nd floor, Aisharya Plaza-I, Sector-H, Aliganj, Lucknow 312, Skyline Plaza-I, Shushant Golf City, Lucknow E-Mail: info.shaleenconsulants@gmail.com Contact No.: +91 9335920481 | +91 8896832308

